



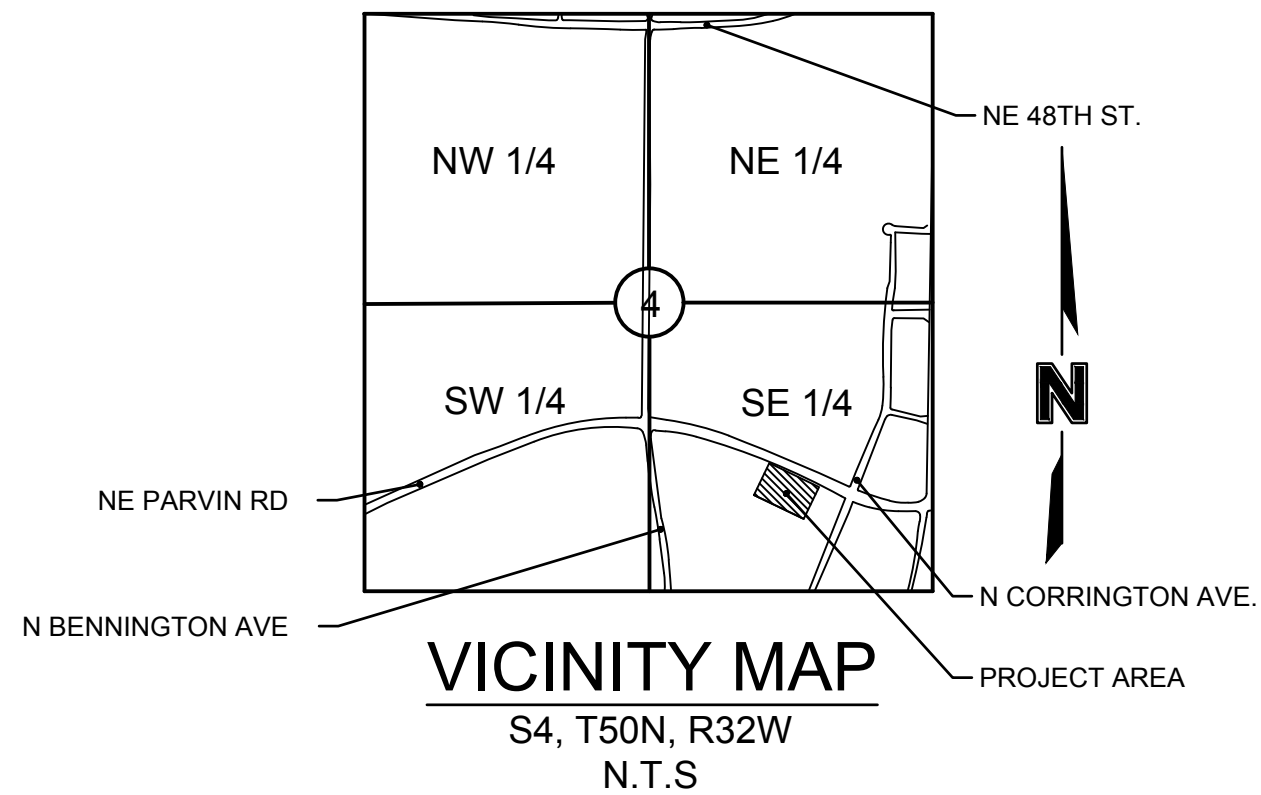

PROJECT TEAM & UTILITY CONTACT LIST	
<u>OWNER</u> MIDWAY FORD TRUCK CENTER INC. 7601 NE 38TH ST. KANSAS CITY, MO 64161 CONTACT: 800.598.2285	<u>UTILITY SERVICE NUMBERS</u> NAME: KCMO PUBLIC WORK PHONE: 816-513-2627 NAME: KCMO WATER SERVICES DEPARTMENT PHONE: 816-513-2171
<u>ENGINEER</u> OLSSON, INC. 1301 BURLINGTON, SUITE 100 NORTH KANSAS CITY, MO 64116 CONTACT: JACOB HODSON PHONE: 816.442.6030 EMAIL: JHODSON@OLSSON.COM	NAME: SPIRE (MGE) PHONE: 314-342-0500 NAME: AT&T PHONE: 800-286-8313 NAME: KCP&L PHONE: 816-471-5275
<u>SURVEYOR</u> OLSSON, INC. 1301 BURLINGTON, SUITE 100 NORTH KANSAS CITY, MO 64116 CONTACT: JASON ROUDEBUSH PHONE: 816.442.6059 EMAIL: JROUDEBUSH@OLSSON.COM	NAME: SPECTRUM (TWC) PHONE: 877-772-2253 NAME: GOOGLE FIBER PHONE: 877-454-6959

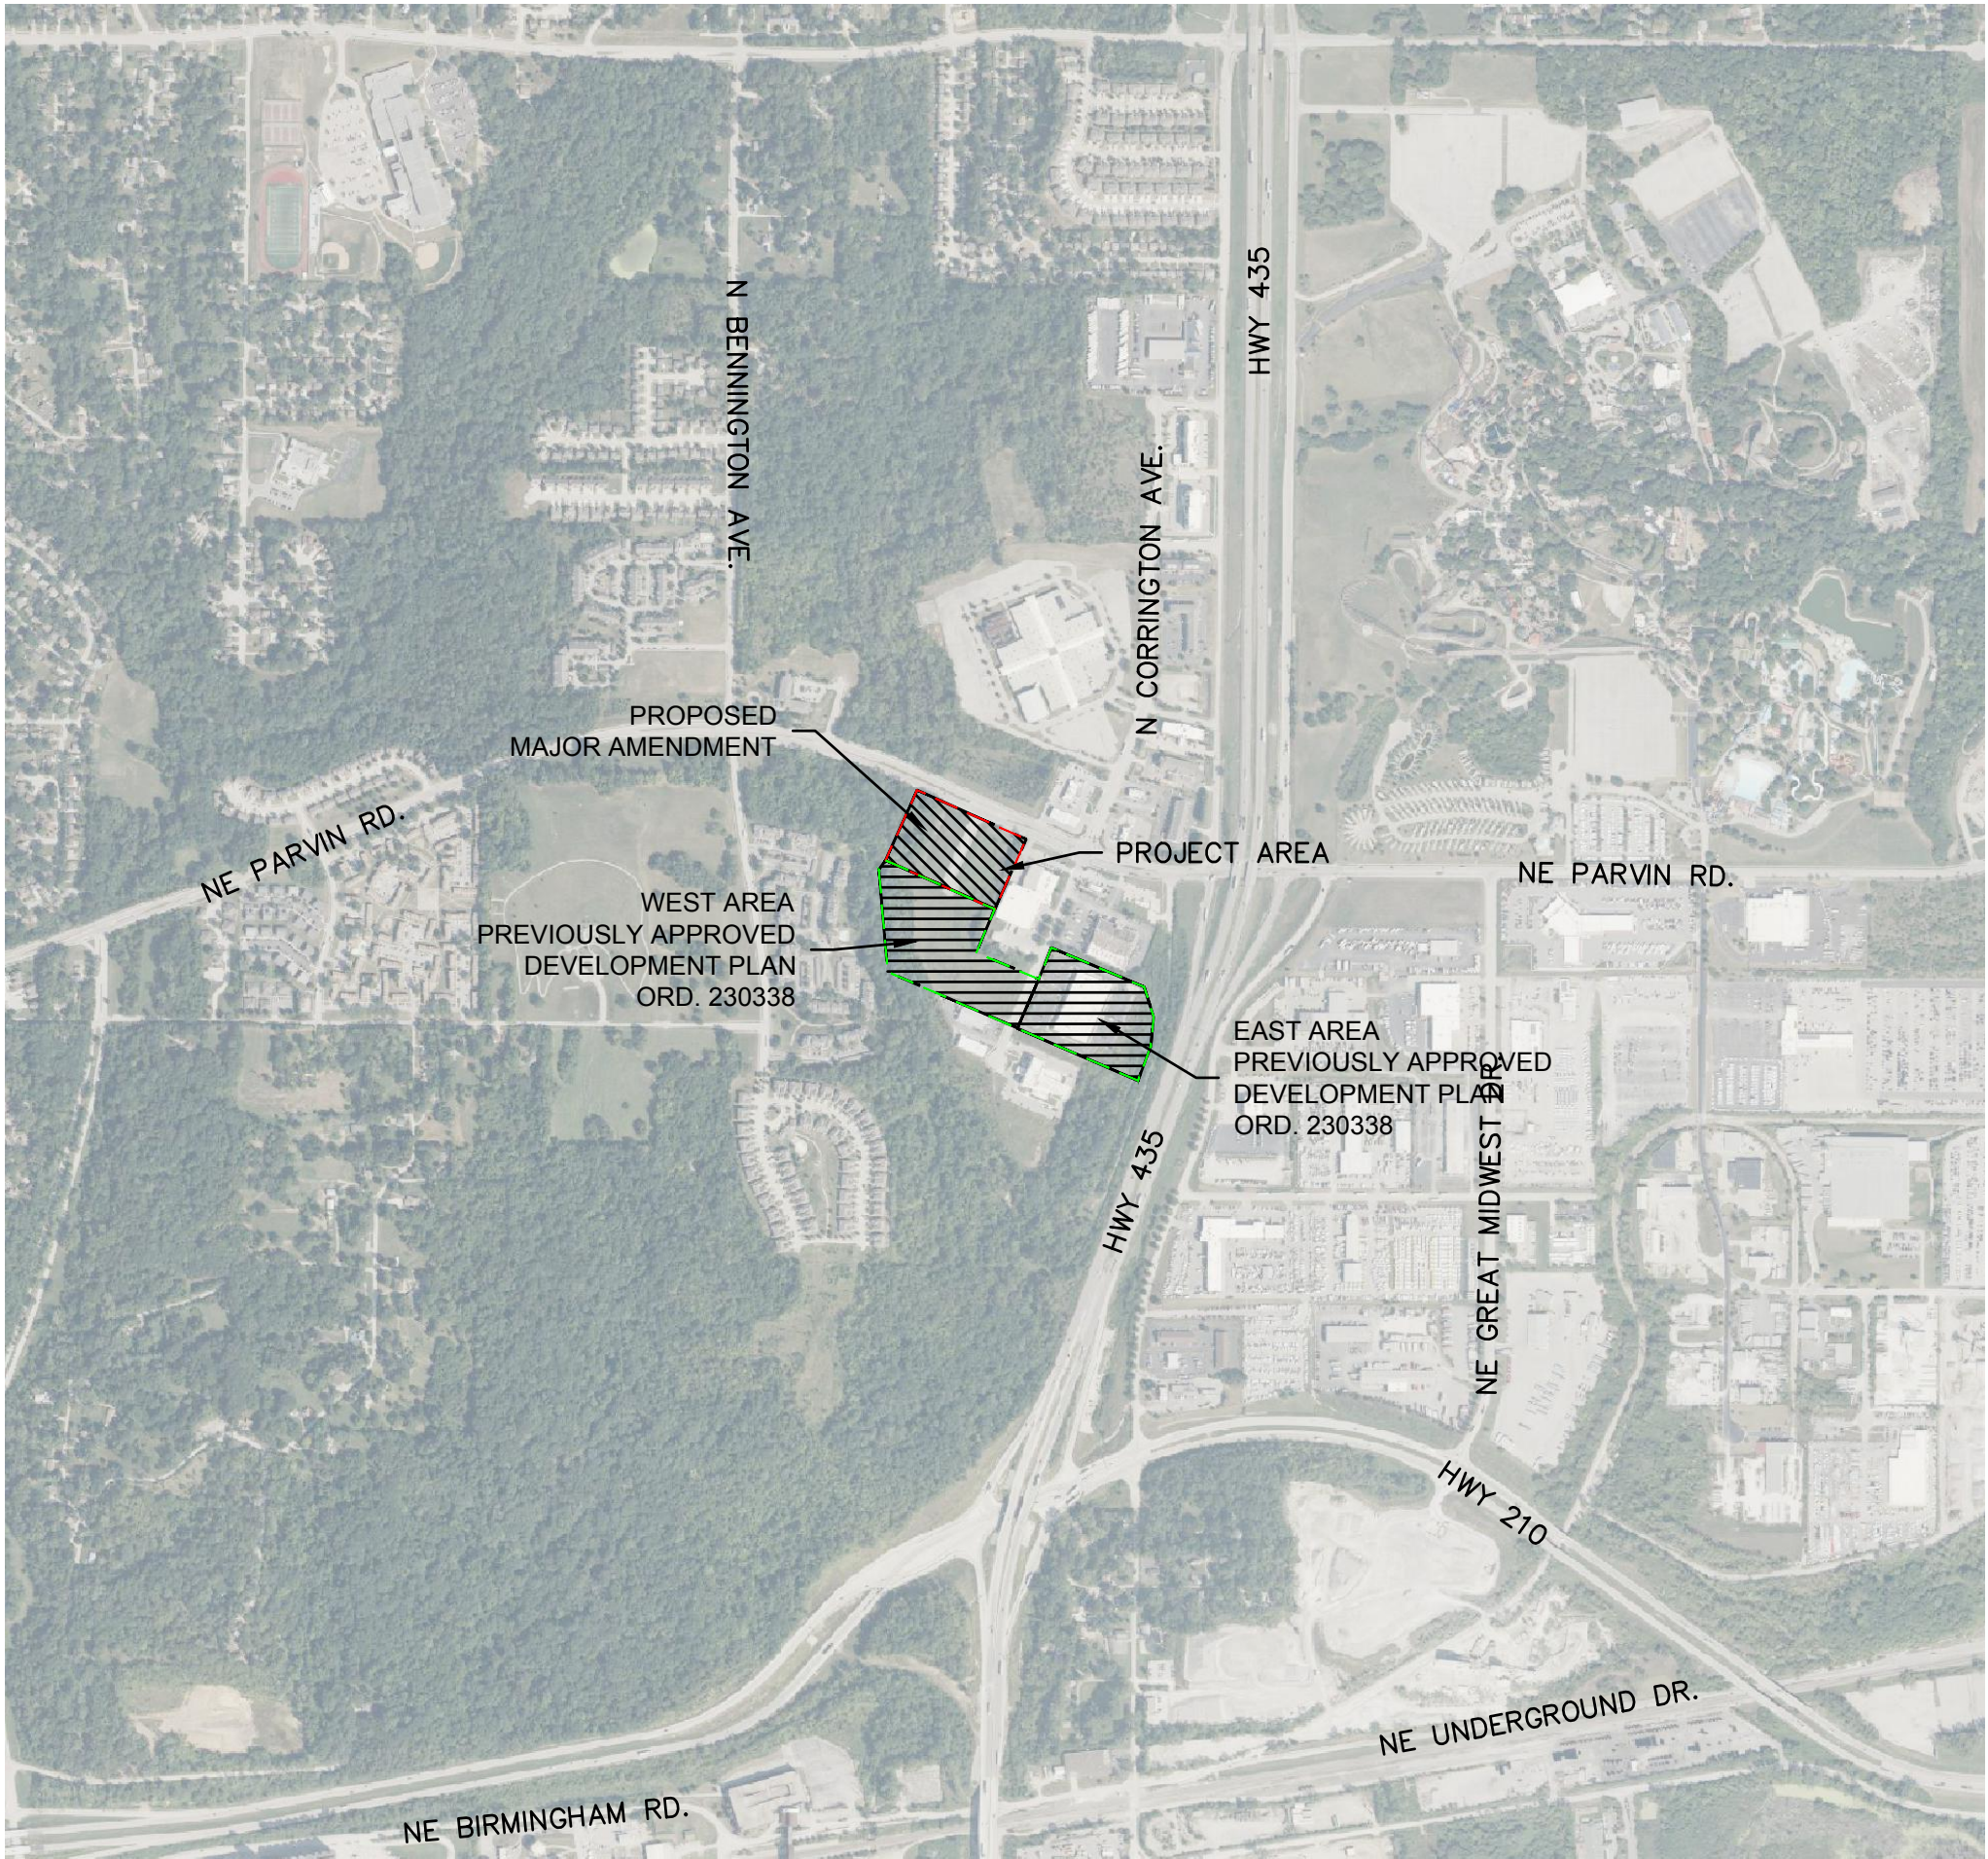

LEGAL DESCRIPTION

HUNT MIDWEST COMMERCE CENTER DISTRICT III 1ST PLAT PT LT 1A (H-43) LYING IN 9-50-32, HUNT MIDWEST COMMERCE CENTER DISTRICT III 1ST PLAT PT LT 1A (H-43) LYING IN 9-50, HUNT MIDWEST COMMERCE CENTER DISTRICT III TR 3B (G-170) A/K/A PT LT 3 BEG NW COR, HUNT MIDWEST COMMERCE CENTER DISTRICT III - SECOND PLAT

SITE DATA	WEST	EAST	MAJOR AMENDMENT AREA
Zoning	M1-5	M1-5	M1-5
Gross Land Area			
in square feet	446,262.00	300,749.00	253,824.13
in acres	10.24	6.90	5.83
Right-of-way Dedication			
in square feet	N/A	N/A	N/A
in acres	N/A	N/A	N/A
Net Land Area			
in square feet	446,262.00	300,749.00	253,824.13
in acres	10.24	6.90	5.83
Building Area (sq. ft.)	520	65,279.00	520
Floor Area Ratio	0.001	0.22	0.0020
LAND USE	WAREHOUSING, WHOLESALEING, STORAGE, AND FREIGHT MOVEMENT (OUTDOOR)	LIMITED MANUFACTURING	WAREHOUSING, WHOLESALEING, STORAGE, AND FREIGHT MOVEMENT (OUTDOOR)

Sheet List Table	
Sheet Number	Sheet Title
C100	TITLE SHEET
C101	EXISTING CONDITIONS
C102	SITE PLAN
C102	EAST SITE PLAN (REF ONLY)
C103	GRADING & UTILITY PLAN
C104	DETAILS
E101	WEST PHOTOMETRIC PLAN
E102	WEST PHOTOMETRIC DETAILS
SL101	EAST PHOTOMETRIC PLAN
SL102	EAST PHOTOMETRIC DETAILS
L101	LANDSCAPE PLAN
L102	LANDSCAPE ELEVATION
A3.1	BUILDING ELEVATIONS
A3.2	BUILDING ELEVATIONS

olsson OLSSON ASSOCIATES - CIVIL ENGINEERING MO CERTIFICATE OF AUTHORITY #001592 1301 BURLINGTON, SUITE 100 NORTH KANSAS CITY, MO 64116 TEL. 816.361.1177 www.olsson.com		NICHOLAS D. HEISER MO PE #2015000555		<table><tr><th colspan="2">REVISIONS DESCRIPTION</th></tr><tr><th>NO. REV.</th><th>DATE</th></tr><tr><td>1</td><td>04.28.2025</td></tr><tr><td> </td><td> </td></tr><tr><td> </td><td> </td></tr><tr><td> </td><td> </td></tr><tr><td> </td><td> </td></tr><tr><td> </td><td> </td></tr><tr><td> </td><td> </td></tr><tr><td> </td><td> </td></tr><tr><td> </td><td> </td></tr></table>		REVISIONS DESCRIPTION		NO. REV.	DATE	1	04.28.2025																
						REVISIONS DESCRIPTION																					
NO. REV.	DATE																										
1	04.28.2025																										
TITLE SHEET DEVELOPMENT PLAN MIDWAY FORD VEHICLE STAGING LOT NE PARVIN & N CORRINGTON AVE		REVISIONS																									
drawn by: _____ JEQ checked by: _____ NH designed by: _____ JEQ QA/QC by: _____ NH project no.: _____ E23-00066 date: _____ 03/31/25		2025																									
SHEET C100		KANSAS CITY, MO																									



VW	VARIABLE WIDTH
DE	STORM DRAINAGE EASEMENT
SBE	STREAM BUFFER EASEMENT
SE	SANITARY SEWER EASEMENT
UE	UTILITY EASEMENT
WE	WATER EASEMENT

LEGEND

————— — ————— PROPERTY BOUNDARIES
 - - - - - EASEMENT & SETBACK BOUNDARIES

PROPOSED CONCRETE PAVEMENT


PROPOSED STANDARD DUTY ASPHALT
OR PERMEABLE PAVEMENT

EAST PLAN (PREVIOUSLY APPROVED)

BUILDING DATA	Required	Existing*	Deviation Requested?	Approved
Rear Setback	None	166' min	N/A	
Front Setback	None	175'	N/A	
Side Setback	None	67'	N/A	
Height	40	<40	N/A	
*Existing building footprint will not be changed				

88-420-PARKING	Vehicle Spaces		Bike Spaces		Alternatives proposed? 88-420-16
	Required	Proposed	Required	Proposed	
Proposed Use (s) (1)	5	176*	1	3**	
(1) – Based on 20 employees					
* Existing parking stalls satisfy this requirement					
** Existing bicycle rack satisfies this requirement					

 * Existing parking stalls satisfy this requirement
** Existing bicycle rack satisfies this requirement



ALL APPROVALS AND CONDITIONS PASSED WITH ORDINANCE 230338 SHALL REMAIN IN AFFECT WITH THIS MAJOR AMINDMENT.

SECURITY OFFICE PLANS SHALL BE SUBMITTED SEPARATELY AT A LATER DATE ALONG WITH ANY UTILITY CONNECTIONS TO SERVE THE OFFICE.

NO ELECTRIC VEHICLE CHARGING WILL BE CONDUCTED ON SITE.




WEST PLAN

88-420-PARKING	VEHICLE SPACES		BIKE SPACES		ALTERNATIVE PROPOSED?
	REQUIRED	PROPOSED	REQUIRED	PROVIDED	
VEHICLE PARKING = 1 PER 4 EMPLOYEES BICYCLE PARKING = 1 PER 4 EMPLOYEES	1 EMPLOYEE = 1 SPACE	4	3 MINIMUM	6 @ 4131 N CORRINGTON AVE.	NO

[illegible]

REVISIONS

SITE PLAN DEVELOPMENT PLAN	
MIDWAY FORD VEHICLE STAGING LOT NE PARVIN & N CORRINGTON AVE	
KANSAS CITY, MO	2025

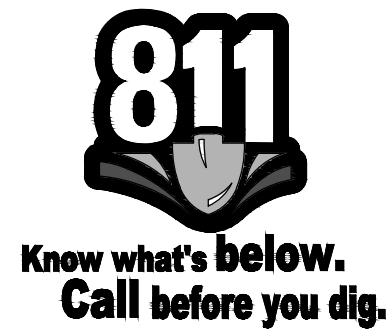

SITE DATA	Existing	Proposed	Deviation Requested?	Approved
Zoning	M1-5	M1-5	N/A	
Gross Land Area - (LOT 1A)				
In Square Feet	300,749.00	300,749.00	N/A	
In Acres	6.90	6.90		
Building Area (sq. ft.)	65,279.00	65,279.00		
Floor Area Ratio	0.22	0.22	N/A	
Total Lots	1	1		
Residential	0	0		
Public/Civic	0	0		
Commercial	0	0		
Industrial	300,749.00	300,749.00		
Other	0	0		

(1) - Lot 1, Platted as Hunt Midwest Commerce Center District III - First Plat

BUILDING DATA	Required	Existing*	Deviation Requested?	Approved
Rear Setback	None	166' min	N/A	
Front Setback	None	175'	N/A	
Side Setback	None	67'	N/A	
Height	40	<40	N/A	

*Existing building footprint will not be changed

88-420-PARKING	Vehicle Spaces		Bike Spaces		Alternatives proposed? 88-420-16
	Required	Proposed	Required	Proposed	
Proposed Use (s) (1)	5	176*	1	3**	

(1) -Based on 20 employees

* Existing parking stalls satisfy this requirement

** Existing bicycle rack satisfies this requirement

LEGAL DESCRIPTION:

LOT 1A (Lot Split)

Lot 1, Hunt Midwest Commerce Center District III - First Plat

CONSTRUCTION NOTES


- (P1) - CONSTRUCT 6" STANDARD DUTY ASPHALT PAVEMENT SECTION OR MATCH EXISTING.
- (P2) - CONSTRUCT 6" HEAVY DUTY CONCRETE PAVEMENT SECTION. REFER TO PAVING DETAILS.
- (P3) - CONSTRUCT 5" THICK CONCRETE SIDEWALK. REFER TO SPOT GRADING PLAN AND SITE DETAILS.
- (P4) - CONSTRUCT CONCRETE SIDEWALK CURB RAMP. ALL RAMPES WILL REQUIRE DETECTABLE WARNING PANELS AND SHALL BE CONSTRUCTED PER DOJ ADA GUIDELINES. SIDEWALK WILL BE ADA COMPLIANT. REFER TO SPOT GRADING PLAN AND SITE DETAILS. (APWA TYPE A SIDEWALK RAMP)
- (P5) - PROPOSED STORMWATER INFRASTRUCTURE. REFER TO STORMWATER PLAN AND DETAILS, SHEET C104.
- (P6) - CONSTRUCT CONCRETE DRIVEWAY RAMPS. REFER TO SPOT GRADE PLAN, SHEET C103.
- (P7) - INSTALL TYPE CG-1 DRY CURB & GUTTER.
- (P8) - INSTALL 35 LF HANDRAIL EACH SIDE OF LOADING DOCK. SEE DETAIL, SHEET C107. INSTALL SWING GATE, ROPE FENCE OR OTHER APPROVED SAFETY MEASURE AT END OF TRUCK DOCK.
- (P9) - FUTURE ASPHALT PARKING LOT EXPANSION. SEE SHEET C200.

PAVEMENT LEGEND

- 6" HEAVY DUTY PORTLAND CEMENT CONCRETE PAVEMENT ON 5" AB-3.
- 6" STANDARD DUTY ASPHALT PAVEMENT ON 4" AB-3 (OR MATCH EXISTING).

NOTES:

1. REFER TO LIGHTING PLAN AND DETAILS FOR RE-LOCATED AND PROPOSED LIGHTING (SHEET SL101).
2. STRIPING SHALL BE PLANNED AND INSTALLED BY CONTRACTOR WITH OWNERS APPROVAL.

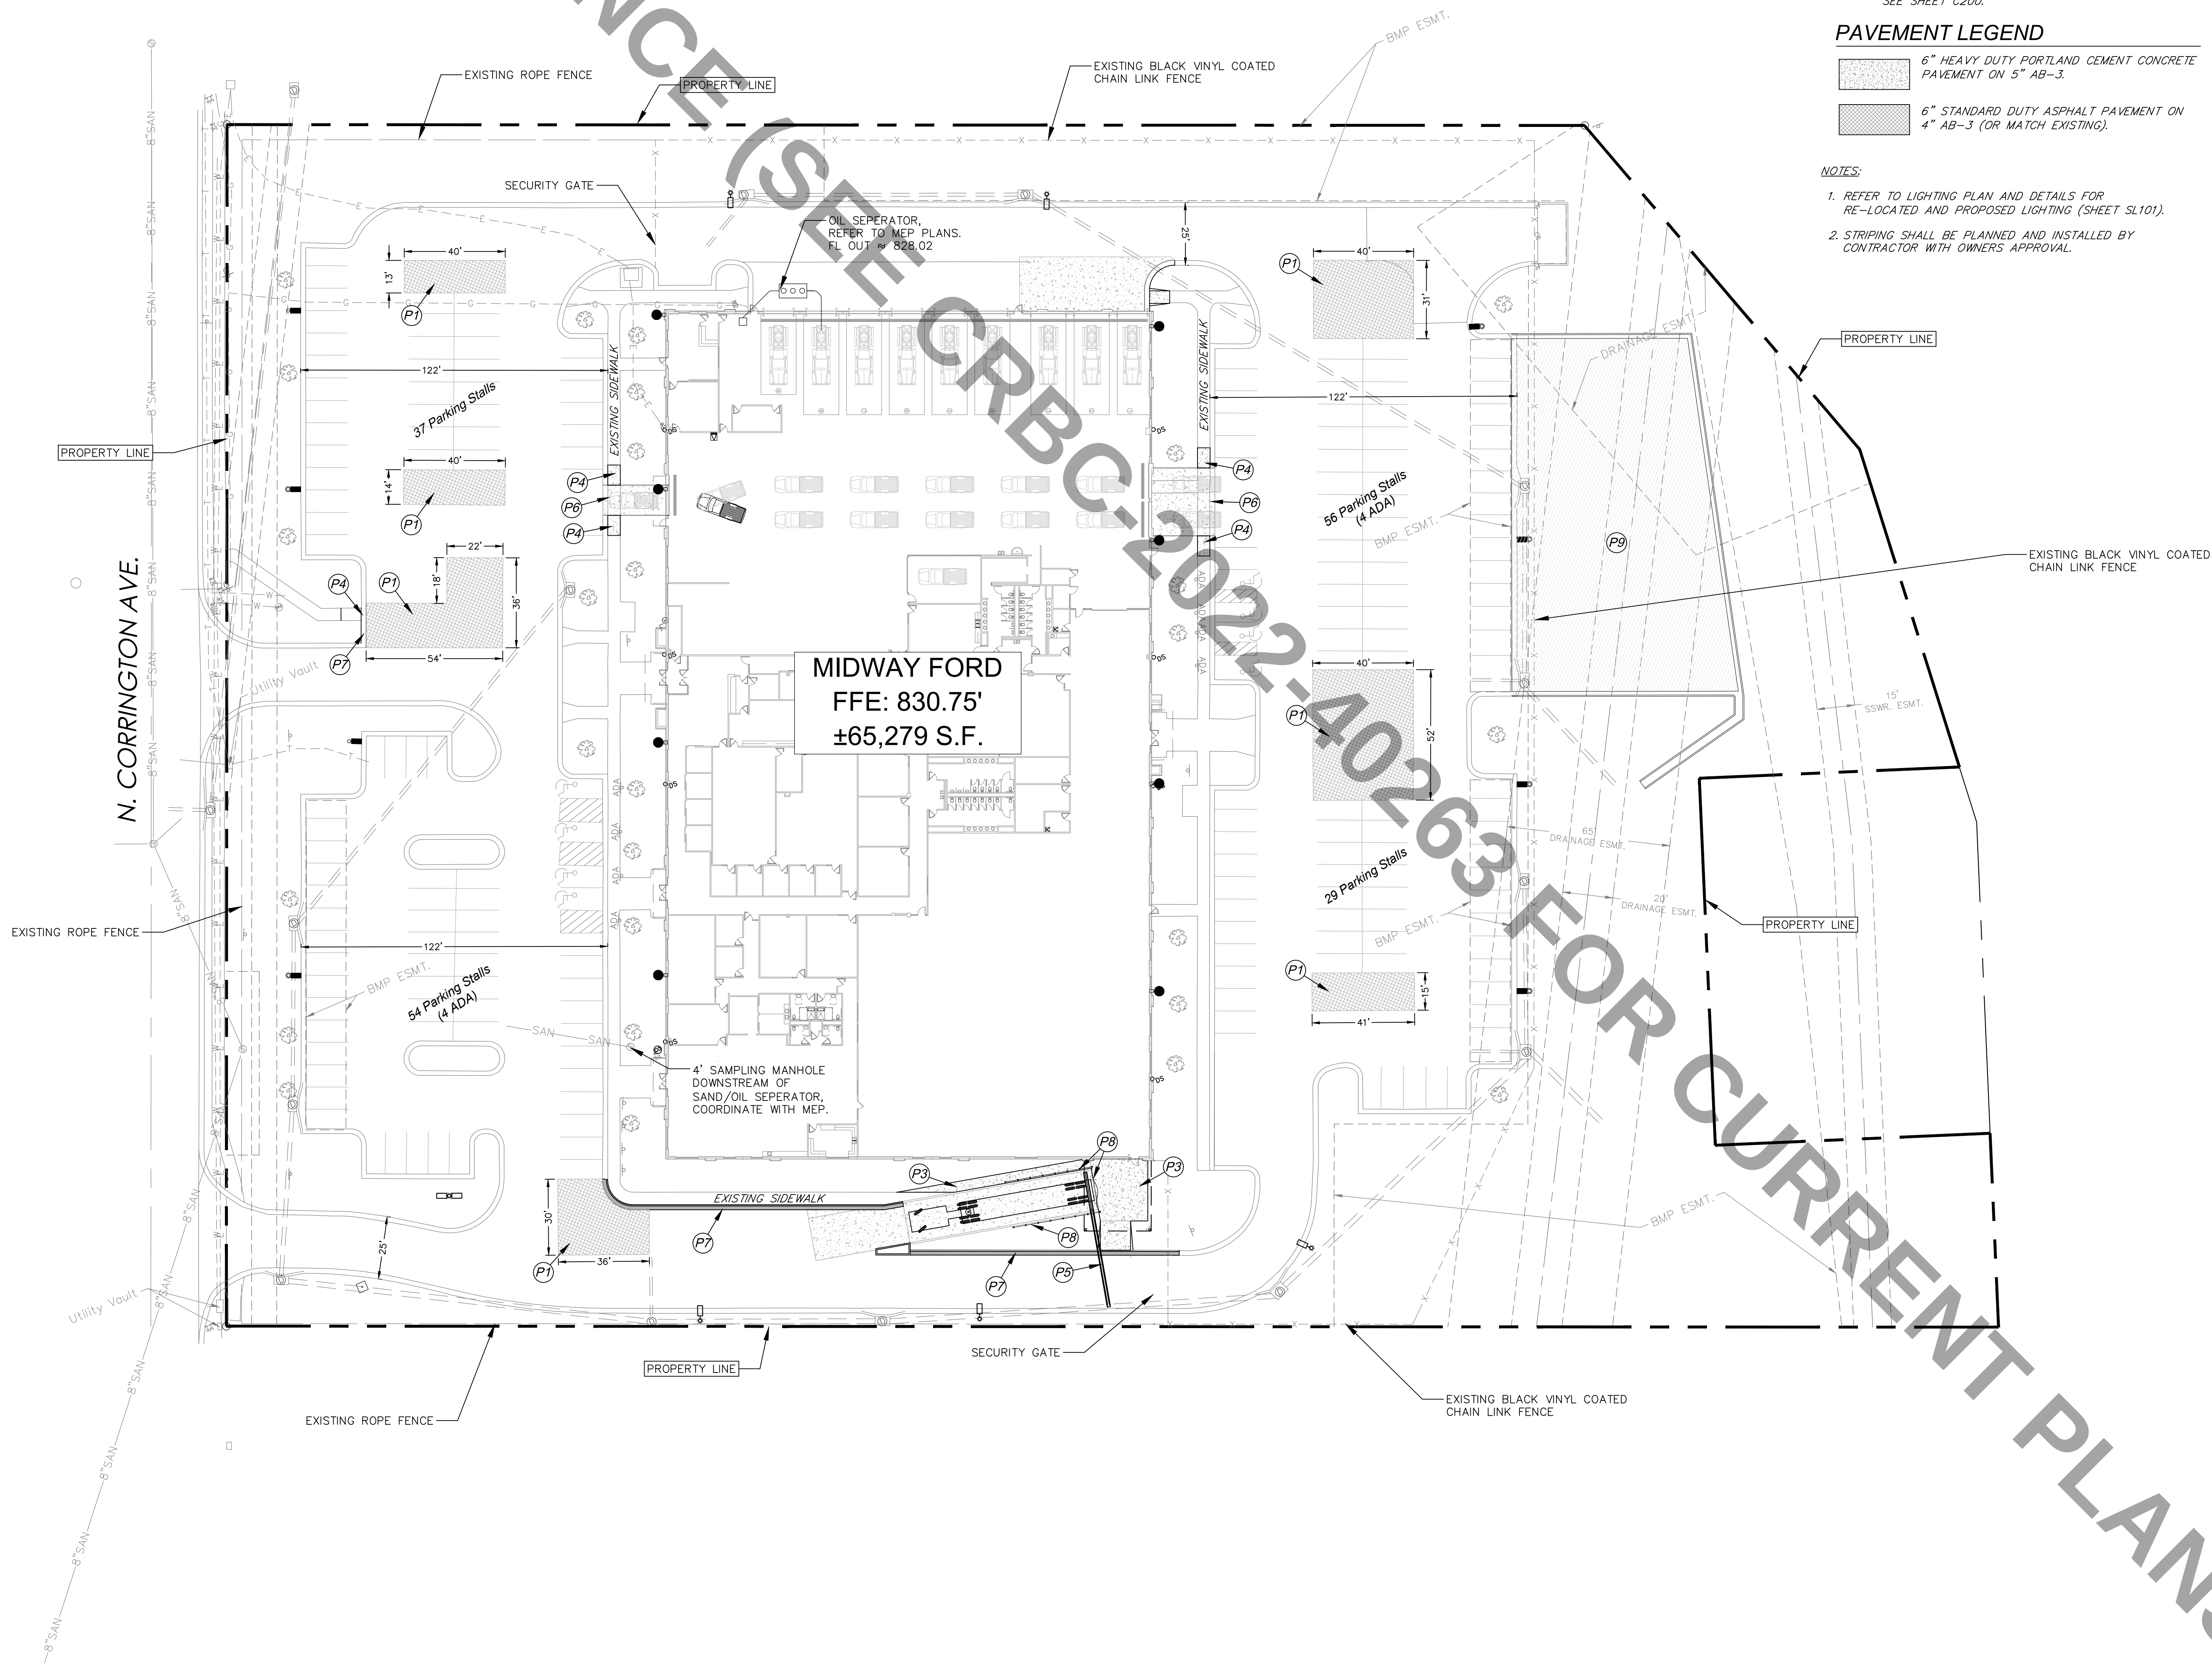


9000 STATE LINE ROAD
LEAWOOD, KANSAS 66206
11006 PARALLEL PARKWAY
KANSAS CITY, KANSAS 66109
TEL (913) 642-6642
FAX (913) 642-6941
www.ccengineers.com

DAVID A. KASTER, RANCARBLEED AP
ARCHITECT
MICHAEL L. HOWARD, ARCHITECT
Copyright © 2022 Kaster Architects, Inc.
7304 WEST 130th STREET
SUITE 1170 PLATEAU, KANSAS 66213
TELEPHONE (913) 681-1200
WEB SITE www.kasterarchitects.com


KASTER ARCHITECTS INC
ARCHITECTURE · PLANNING · INTERIOR DESIGN

MIDWAY FORD
FORMER VATTEROTT BLDG.
4131 N. CORRINGTON AVE.
KANSAS CITY, MISSOURI


DATE FEB. 8, 2023
REVISIONS
SHEET NUMBER
C102
SITE PLAN
OF SHEETS
KAI JOB NO. 2214-A

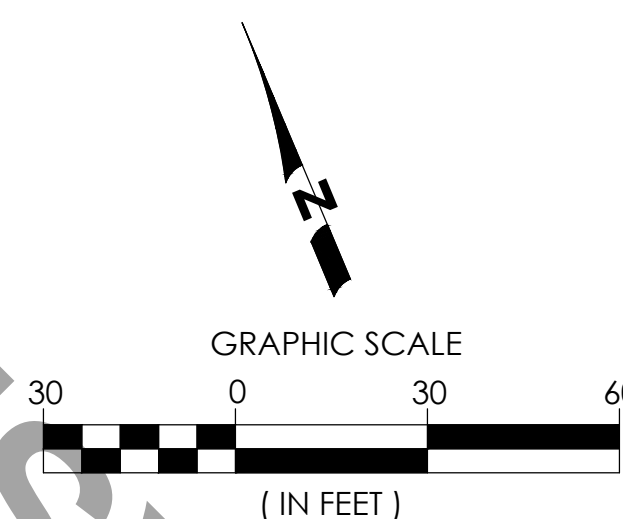


DWG: F:\2023\00001-00500\023-00066-e\40-design\AutoCAD\preliminary plans\Sheets\SDN\C_GROD1_02300066.dwg
XREFS: C:\PAT1_02300066 C:\PBLK_02300066 C:\PBASE_PUBLC_E2300066 C:\PBASE_E2300066
DATE: Apr 25, 2025 5:16pm USER: hodson C_XBASE_E2300066

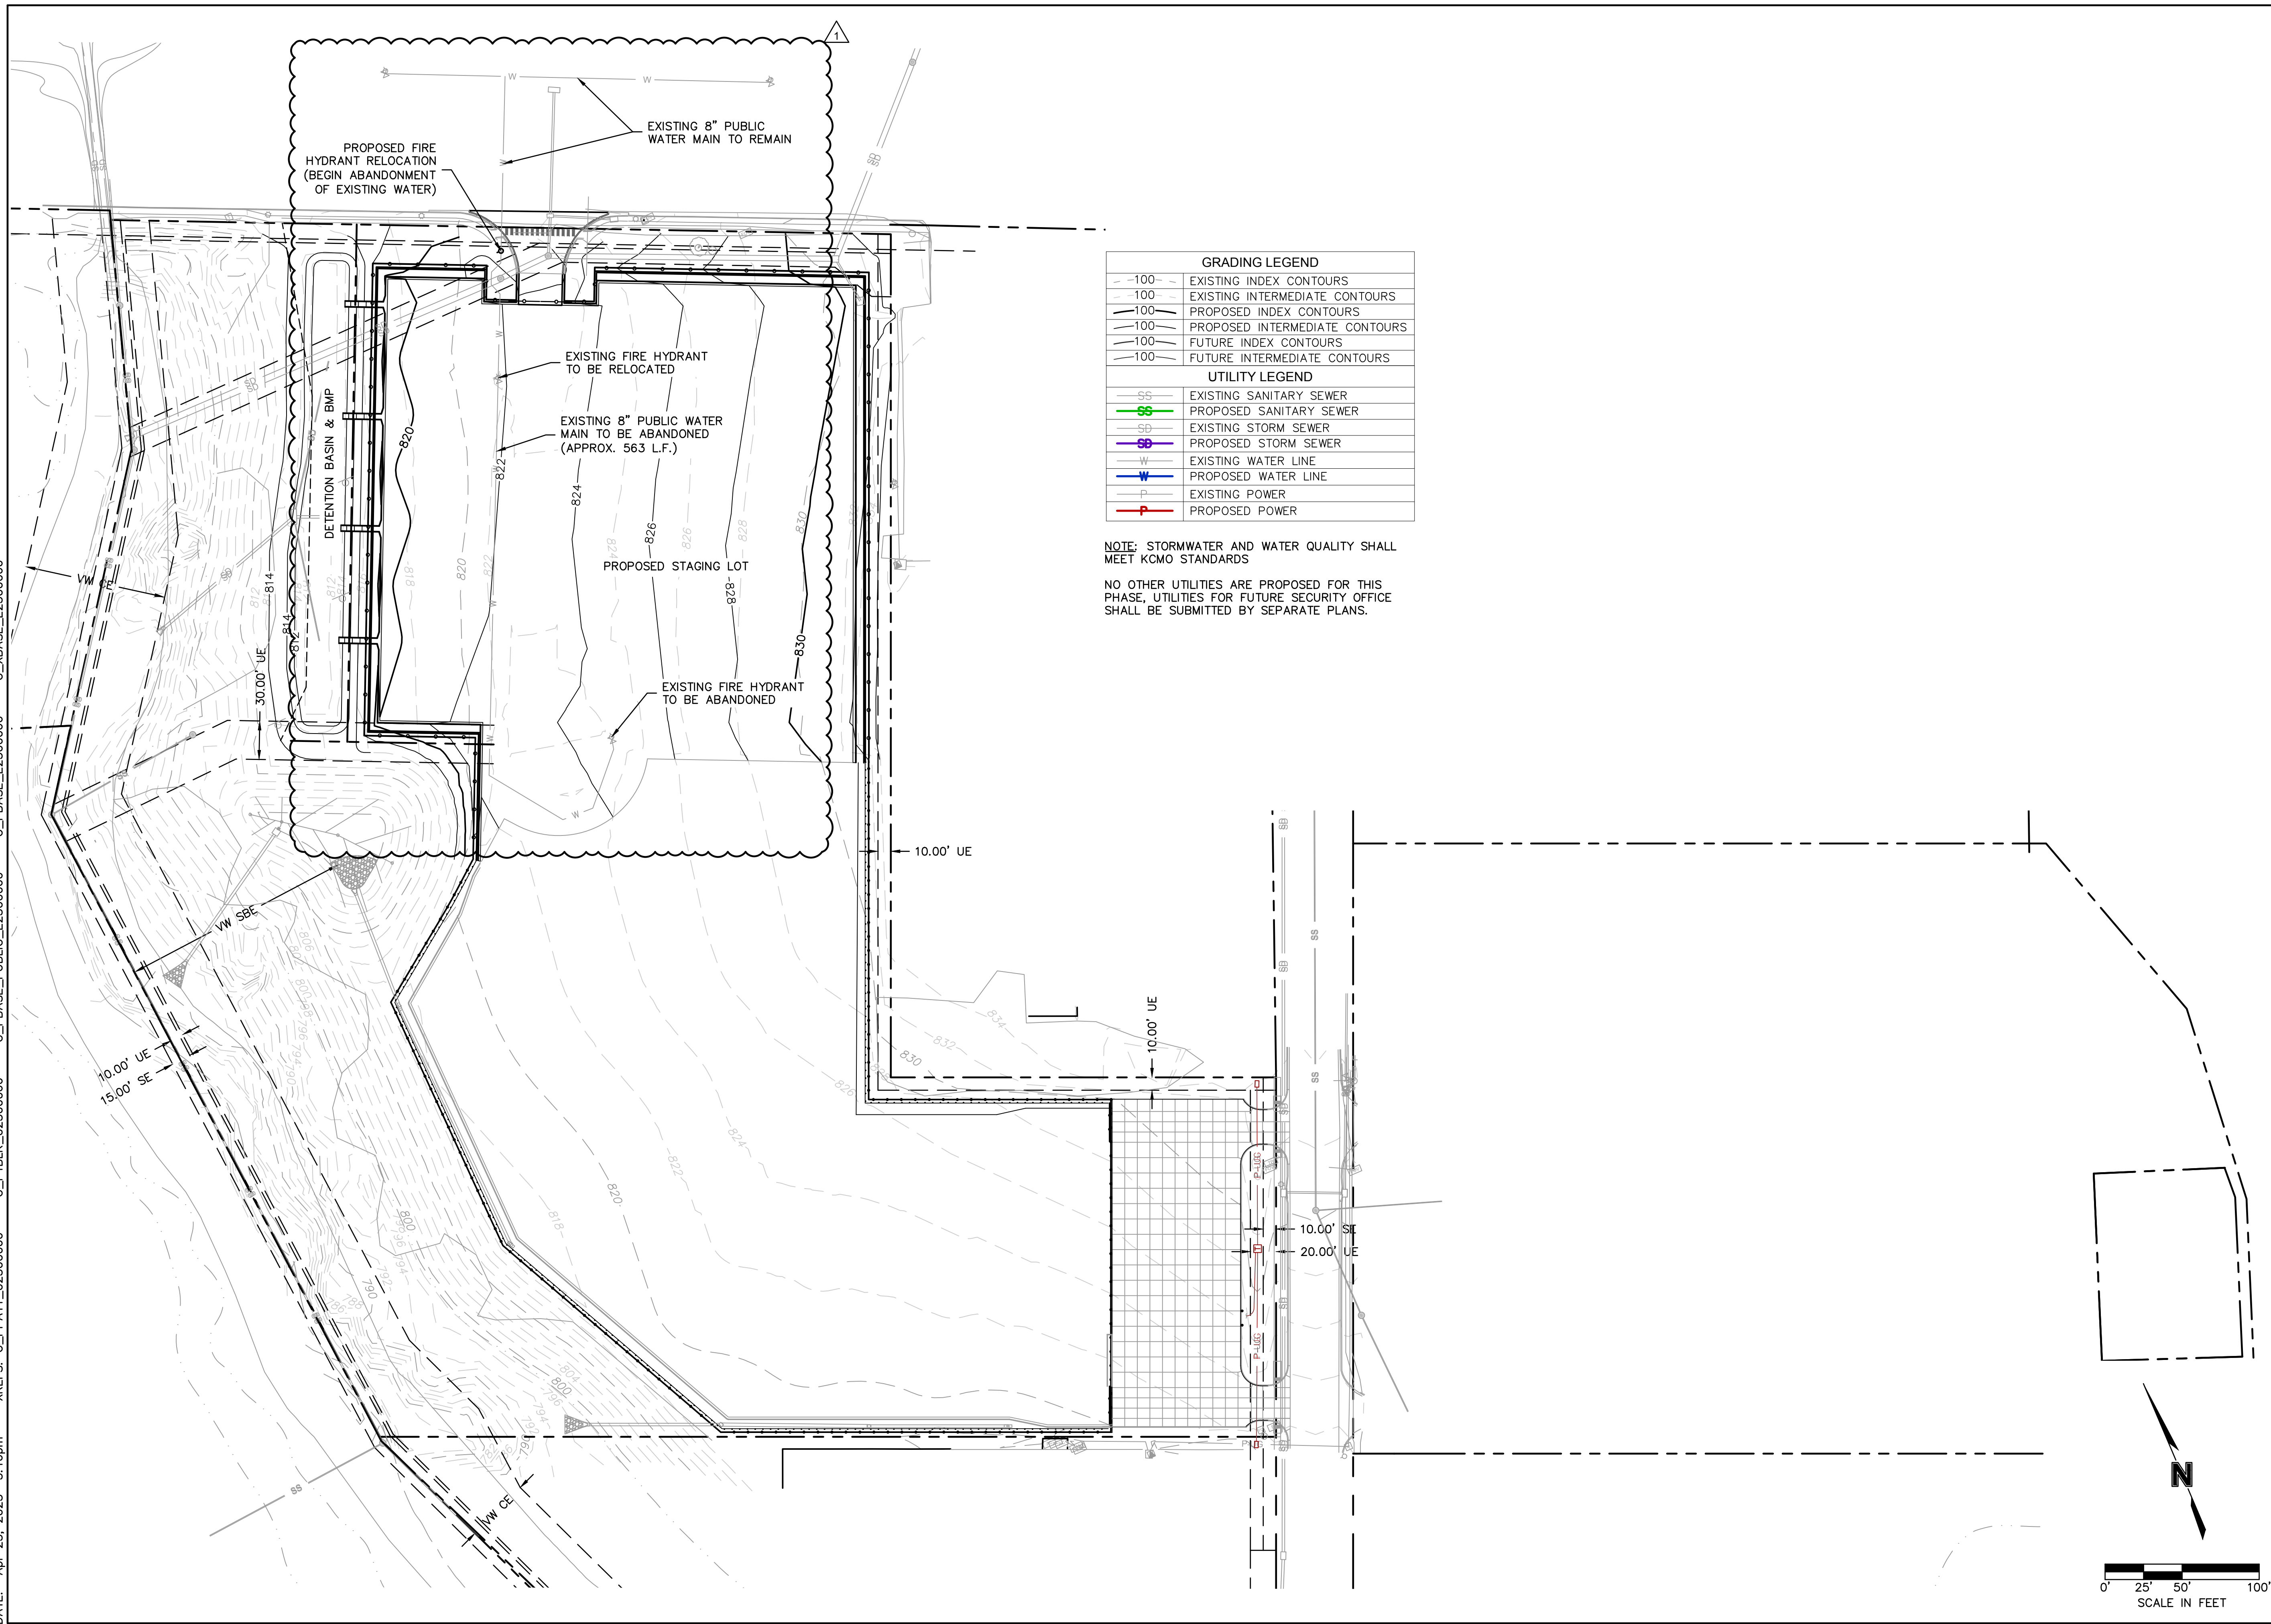[illegible]


DWG: F:\2023\00001-00500\023-00066-e\40-design\AutoCAD\preliminary plans\Sheets\SON\VC_DTL01_02300066.dwg
DATE: Apr 25, 2025 5:16pm
XREFS: C_PTBK_30x42_02103540
USER: Jpodson

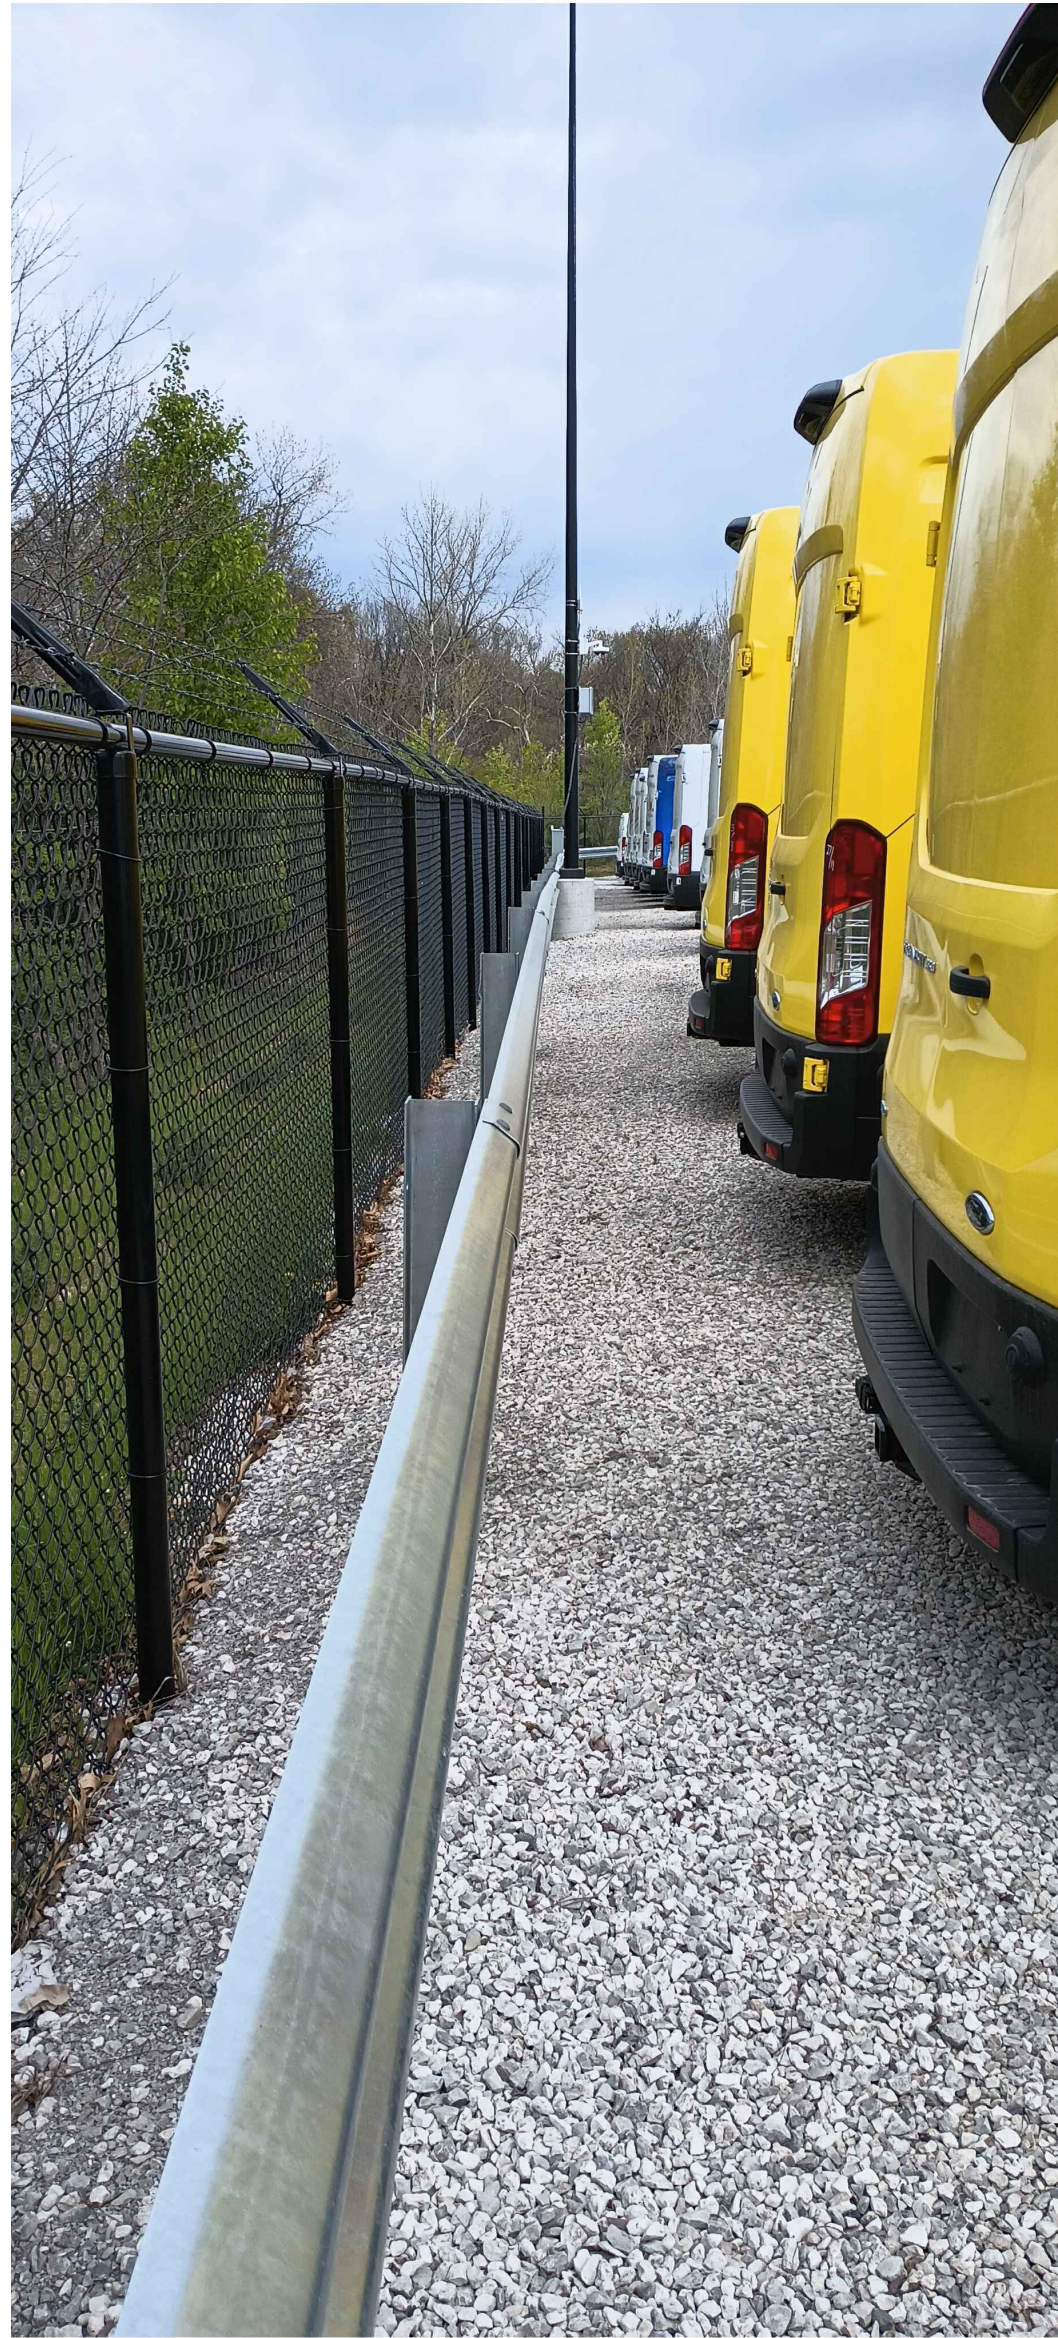

FENCE ELEVATION
NOT TO SCALE

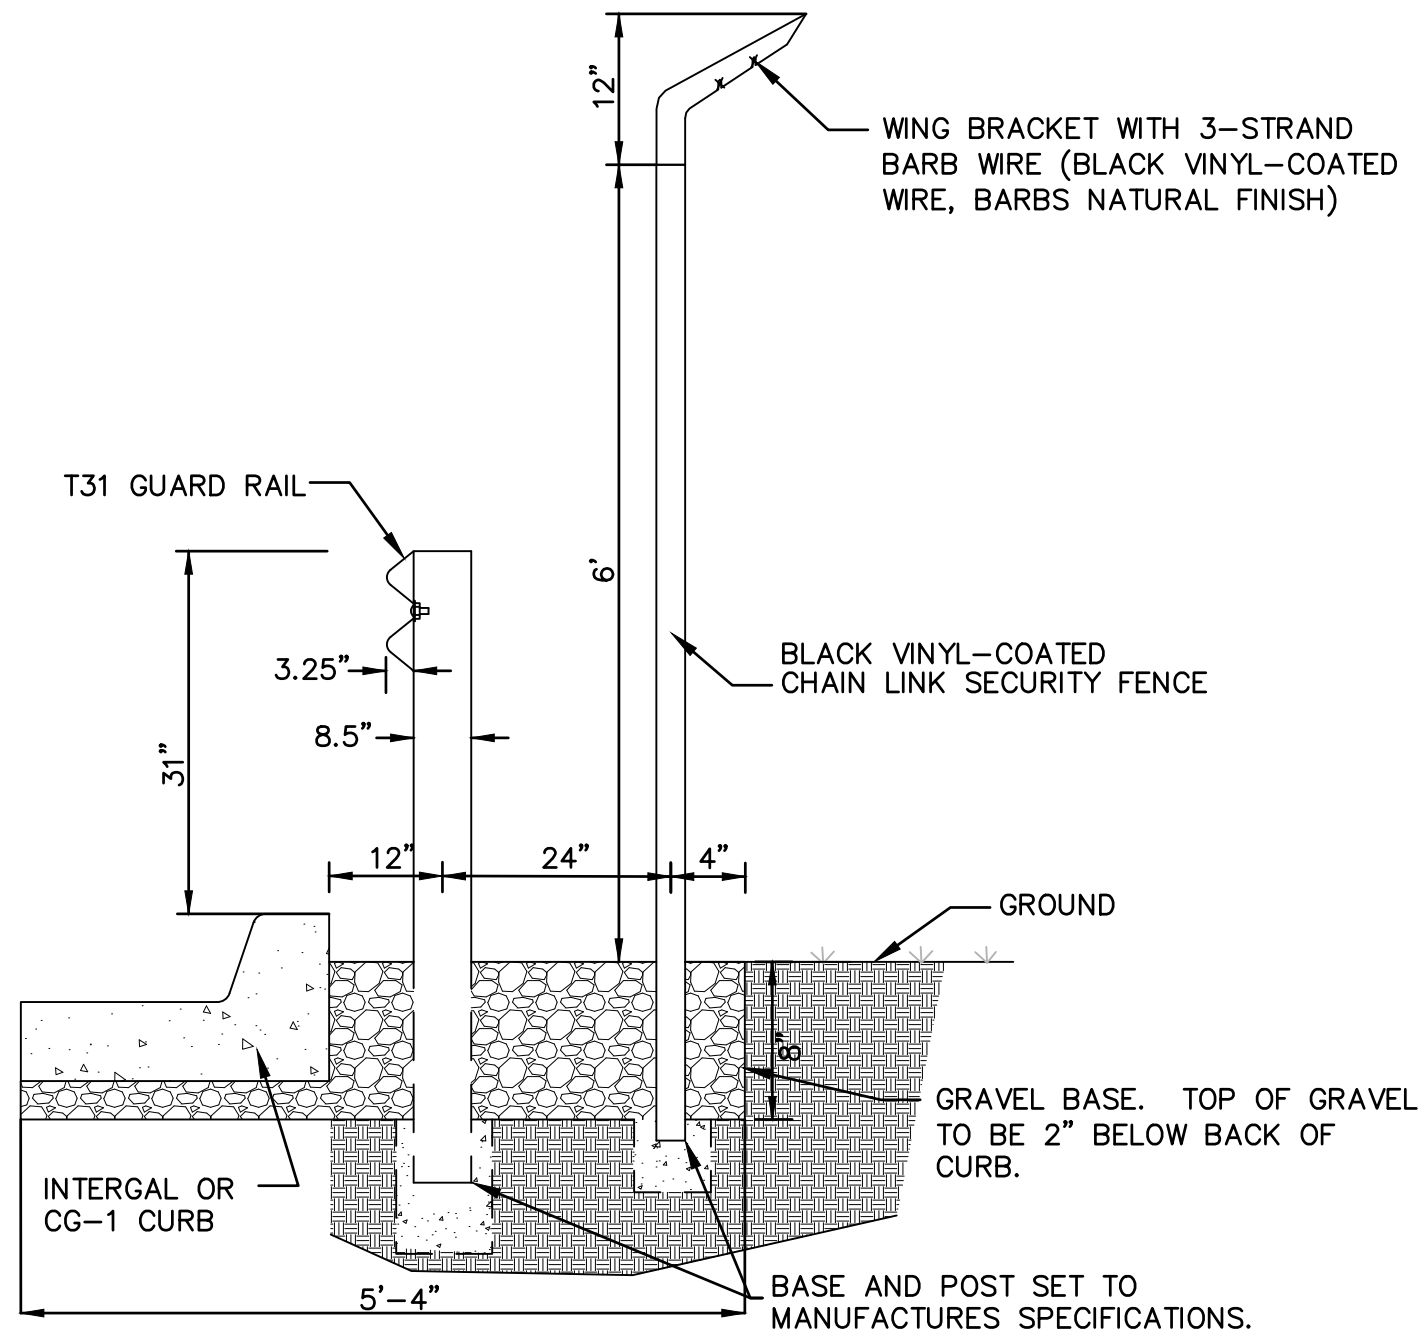

GUARDRAIL/FENCE DETAIL
NOT TO SCALE

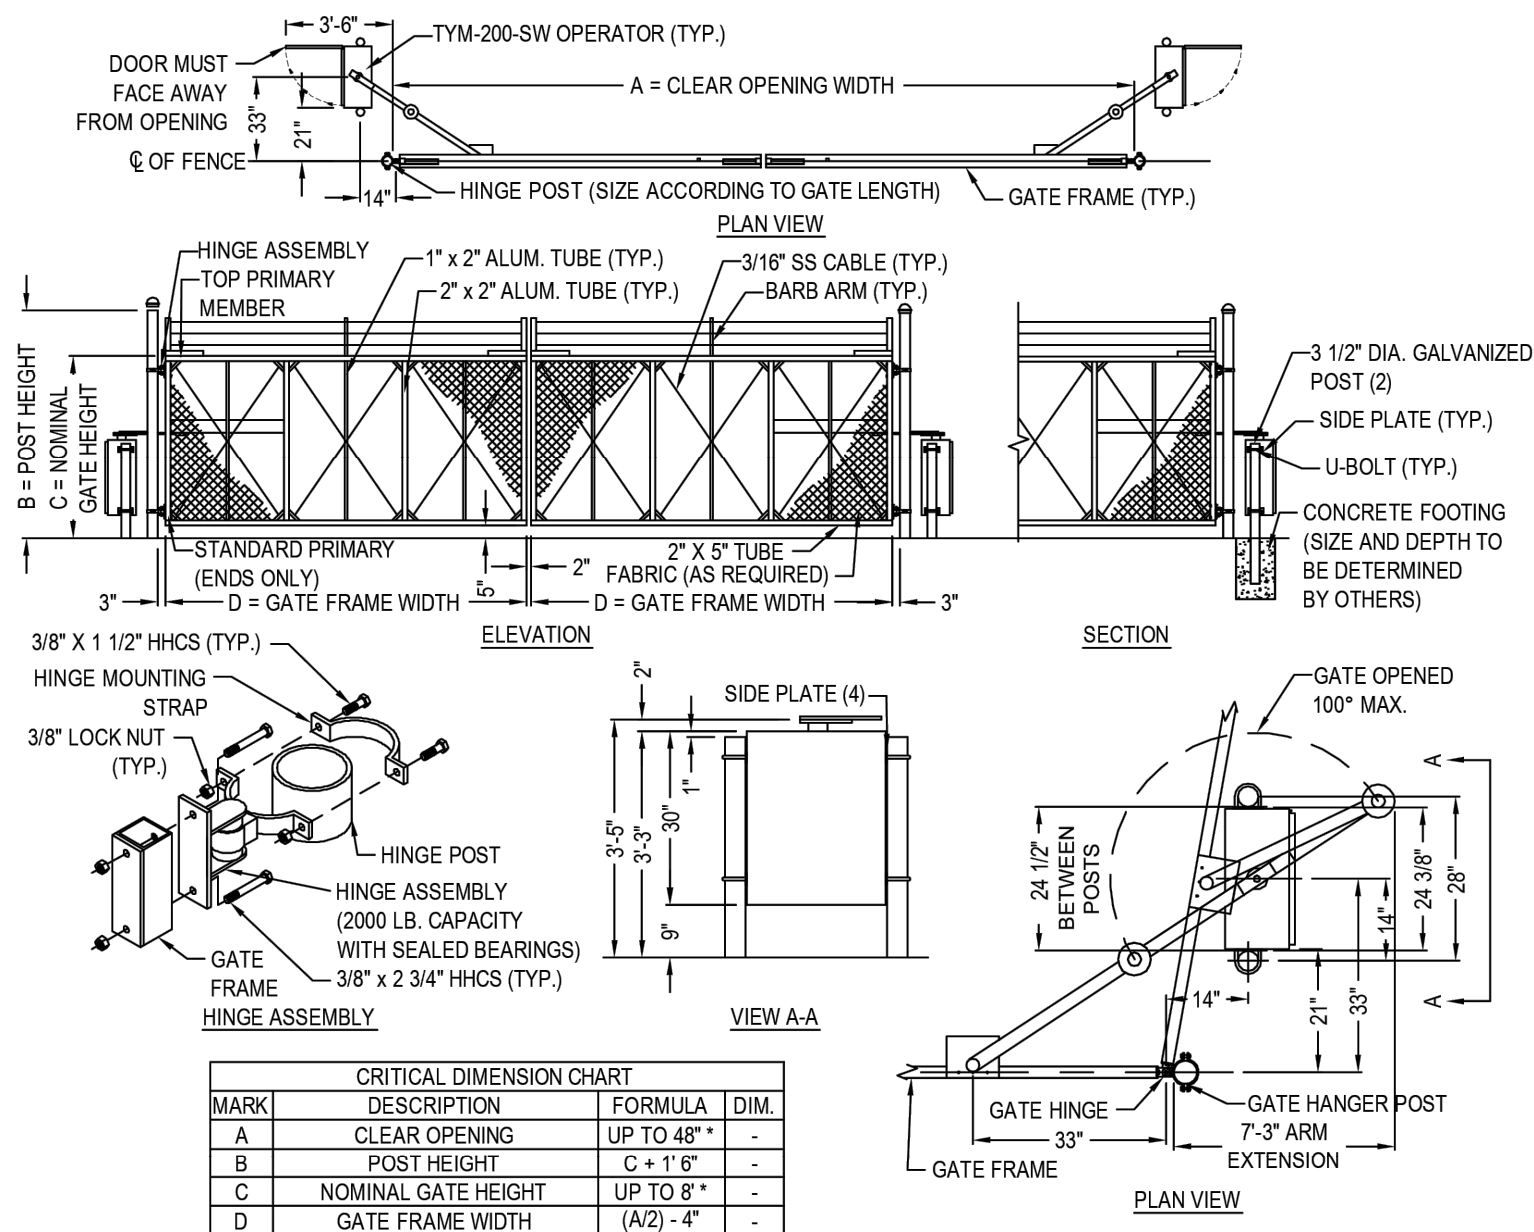

- NOTES:
1. ALL FITTINGS PROVIDED FOR 4" O.D. POSTS. OTHER SIZES ARE AVAILABLE UPON REQUEST.
 2. GATE ELEVATION IS VIEWED FROM THE OUTSIDE OF THE SECURE AREA LOOKING IN.
 3. * CRITICAL DIMENSION A = SINGLE PANEL: 6'-0" MIN. - 24'-0" MAX. DOUBLE: 12'-0" MIN - 48'-0" MAX .
 4. ** CRITICAL DIMENSION E = 4'-0" MIN - 8'-0" MAX (OR CONTACT TIME/TAL)
 5. INSTALLATION TO BE COMPLETED IN ACCORDANCE WITH MANUFACTURER'S SPECIFICATIONS.
 6. DO NOT SCALE DRAWING.
 7. THIS DRAWING IS INTENDED FOR USE BY ARCHITECTS, ENGINEERS, CONTRACTORS, CONSULTANTS AND DESIGN PROFESSIONALS FOR PLANNING PURPOSES ONLY. THIS DRAWING MAY NOT BE USED FOR CONSTRUCTION.
 8. ALL INFORMATION CONTAINED HEREIN WAS CURRENT AT THE TIME OF DEVELOPMENT BUT MUST BE REVIEWED AND APPROVED BY THE PRODUCT MANUFACTURER TO BE CONSIDERED ACCURATE.

FENCE GATE DETAIL
NOT TO SCALE

REVISIONS DESCRIPTION

NO. REV. DATE

DETAILS
DEVELOPMENT PLAN

MIDWAY FORD VEHICLE STAGING LOT
NE FARVIN & N CORRINGTON AVE

KANSAS CITY, MO


2025

drawn by: JEQ
checked by: NH
designed by: JEQ
QA/QC by: NH
project no: F23-00066
date: 03/31/25

SHEET
C104

olsson

OLSSON - CIVIL ENGINEERING
1301 BUREAU BLVD, SUITE 100
NORTH KANSAS CITY, MO 64116
TEL: 816.361.1177
www.olsson.com

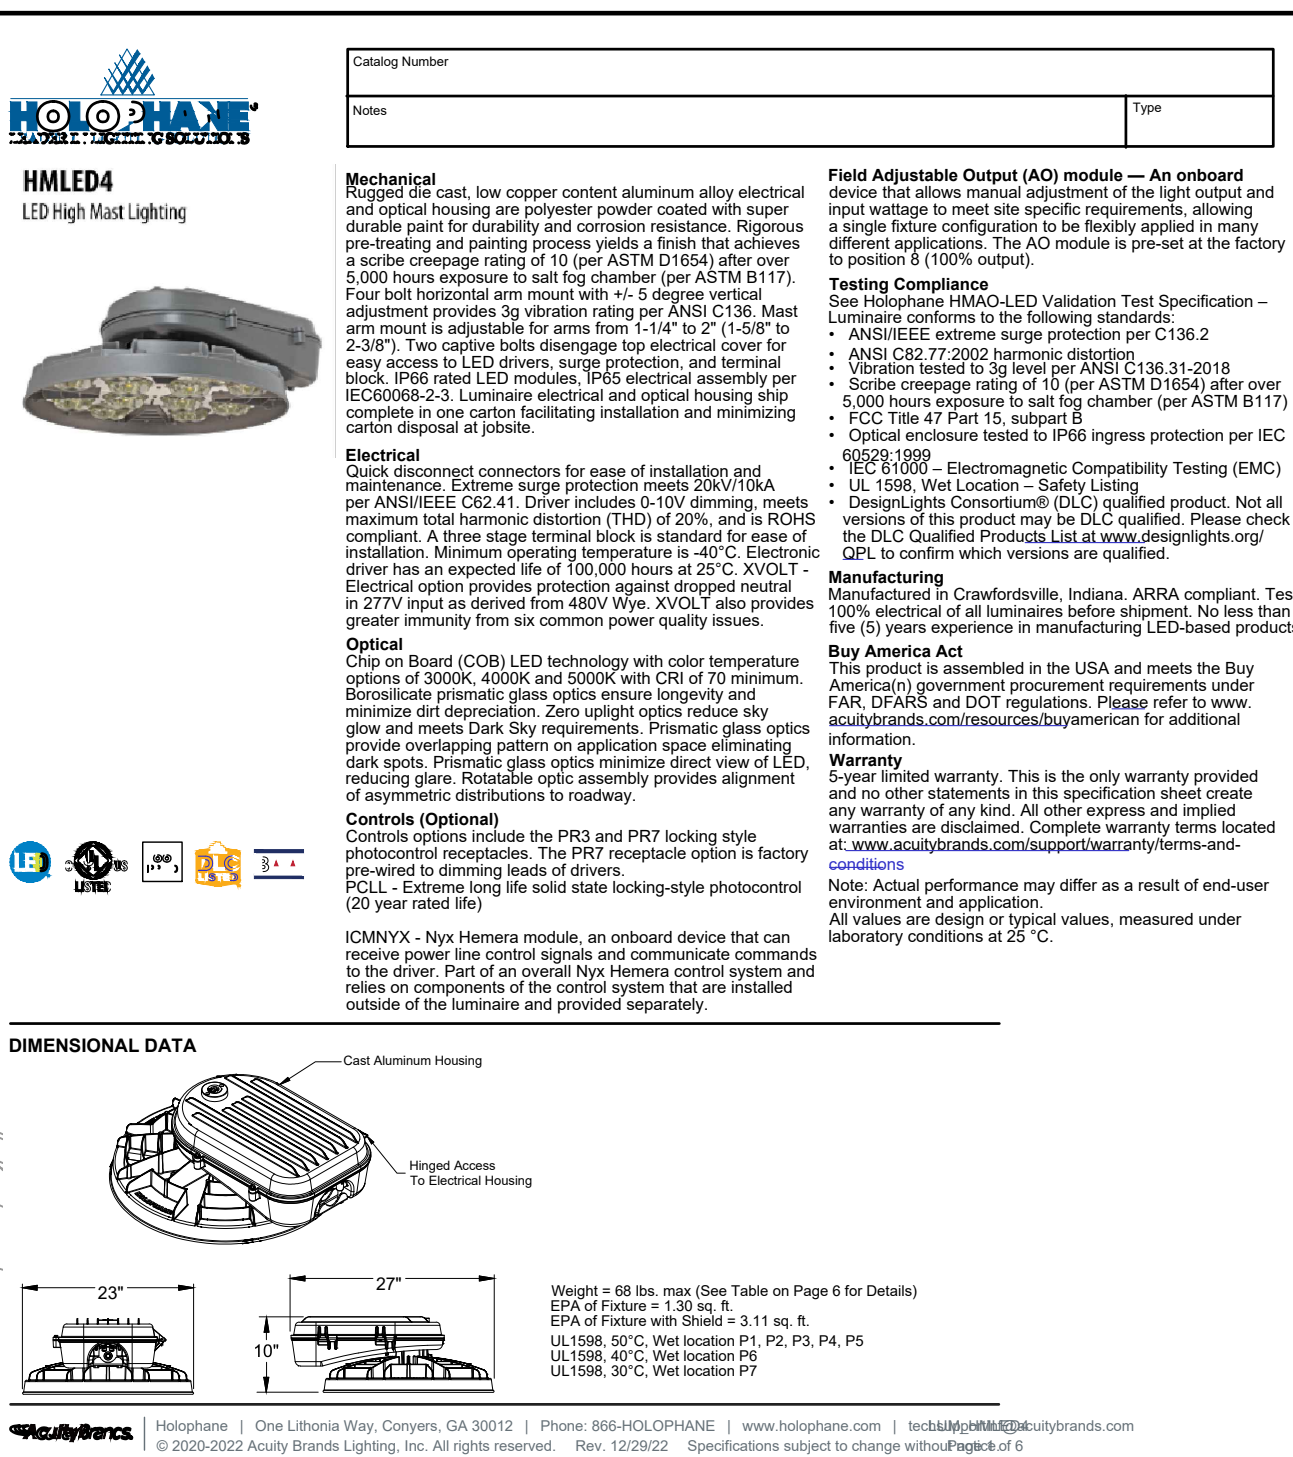[illegible]

FOR REFERENCE (SEE CRBC-2020-033 FOR CURRENT PLANS)

WEST Parking Grid
420 points at z=0, sp 10ft by 10ft
HORIZONTAL FOOTCANDLES
Average 3.5
Maximum 8.8
Minimum 1.0
Avg/Min 3.45
Max/Min 8.80
Coef Var 0.51
UnifGrad 1.70

NORTH Drive Grid
132 points at z=0, sp 10ft by 10ft
HORIZONTAL FOOTCANDLES
Average 2.4
Maximum 7.3
Minimum 0.5
Avg/Min 4.83
Max/Min 14.60
Coef Var 0.48
UnifGrad 3.40

MIDWAY FORD
FFE: 830.75'
±65,279 S.F.

SOUTH Drive Grid
170 points at z=0, sp 10ft by 10ft
HORIZONTAL FOOTCANDLES
Average 2.2
Maximum 4.9
Minimum 0.5
Avg/Min 4.49
Max/Min 9.80
Coef Var 0.41
UnifGrad 2.55

PL GRID
246 points
HORIZONTAL FOOTCANDLES
Average 0.4
Maximum 2.1
Minimum 0.0
Avg/Min N/A
Max/Min N/A
Coef Var 1.21

EAST Parking Grid
376 points at z=0, sp 10ft by 10ft
HORIZONTAL FOOTCANDLES
Average 3.2
Maximum 8.4
Minimum 1.1
Avg/Min 2.89
Max/Min 7.64
Coef Var 0.56
UnifGrad 2.04

○ LIGHT POLE TO BE REMOVED
(LIGHT POLES MAY BE RELOCATED
AND RE-USED AT OWNERS REQUEST)

TYPE "A"
Lithonia Lighting DSX2 LED P8 40K T4M MVOLT
SCALED PHOTOMETRY test report no. ISF 34053P23
lamp(s): LED
ballast: LED DRIVER
candela file DSX2_LED_P8_40K_T4M_MVOLT.ies
1 lamp(s) per luminaire, photometry is absolute
Light Loss Factor = 0.900, watts per luminaire = 431
Outreach (from mounting axis to photometric center) = 30 in
mounting height = 28 ft
number locations = 9, number luminaires = 9
kw all locations = 3.9

TYPE "B"
Lithonia Lighting DSX1 LED P6 40K BLC MVOLT
SCALED PHOTOMETRY test report no. ISF 33923P17
lamp(s): LED
ballast: LED DRIVER
candela file DSX1_LED_P6_40K_BLC_MVOLT.ies
1 lamp(s) per luminaire, photometry is absolute
Light Loss Factor = 0.900, watts per luminaire = 163
Outreach (from mounting axis to photometric center) = 30 in
mounting height = 28 ft
number locations = 5, number luminaires = 5
kw all locations = 0.8

TYPE "C"
Lithonia Lighting DSXW2 LED P6 40K 1000 40K T4M MVOLT
SCALED PHOTOMETRY test report no. 22604P15
lamp(s): NICHIA 2198 4000K
ballast: LEDINTA350C210DHO
candela file DSXW2_LED_P6_40K_1000_40K_T4M_MVOLT.ies
1 lamp(s) per luminaire, photometry is absolute
Light Loss Factor = 0.900, watts per luminaire = 109
Outreach (from mounting axis to photometric center) = 8 in
mounting height = 18 ft
number locations = 9, number luminaires = 9
kw all locations = 1.0




9000 STATE LINE ROAD
LEAWOOD, KANSAS 66206
11006 PARALLEL PARKWAY
KANSAS CITY, KANSAS 66109
TEL (913) 642-6642
FAX (913) 642-6641
www.ccengineers.com

DAVID A. KASTER, RANCABLEE AP
ARCHITECT
MICHAEL L. HOWARD, ARCHITECT
Copyright © 2022 Kaster Architects, Inc.
7304 WEST 130th STREET
SUITE 170 PARK KANSAS 66213
TELEPHONE (913) 681-1200
WEB SITE www.kasterarchitects.com

KASTER ARCHITECTS INC
ARCHITECTURE · PLANNING · INTERIOR DESIGN

MIDWAY FORD
FORMER VATTEROTT BLDG.
4131 N. CORRINGTON AVE.
KANSAS CITY, MISSOURI

DATE FEB. 8, 2023
REVISIONS
SHEET NUMBER
SL101
SITE LIGHTING
AND PHOTOMETRICS
OF SHEETS
KAI JOB NO. 2214-A

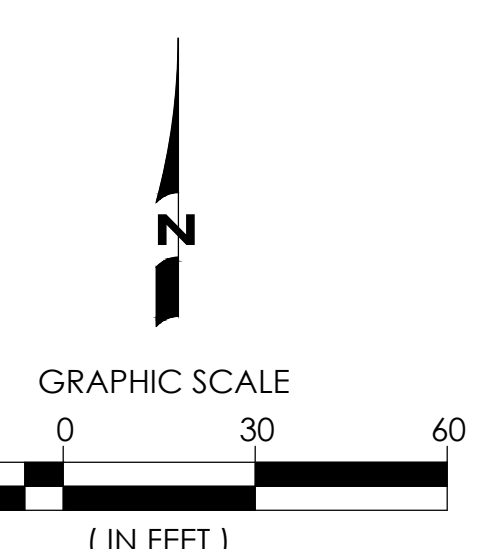

TYPE A LIGHTING FIXTURE



D-Series Size 2 LED Area Luminaire

Specifications

EPA: 1.1 ft
Length: 40"
Width: 15"
Height 1: 7.14"
Height 2: 3.5"
Weight: 36lb

Ordering Information

EXAMPLE: DSX2 LED P7 40K T3M MVOLT SPA NLTAIR2 PIRHN DBB2D

DSX2 LED	LEDs	Color Temperature	DSX2 Features	Accessories	Mounting
DSX2 LED	Forward optics	30K 3000K	T5 Type I Start	T5 Type I Start	DSX2
P1	P2	40K 4000K	T5 Type I Start	T5 Type I Start	DSX2
P2	P6	50K 5000K	T5 Type I Start	T5 Type I Start	DSX2
P1	P7		T5 Type I Start	T5 Type I Start	DSX2
P4	P6		T5 Type I Start	T5 Type I Start	DSX2
DSX2 LED	Recessed optics		T5 Type I Start	T5 Type I Start	DSX2
P1	P2		T5 Type I Start	T5 Type I Start	DSX2
P4	P6		T5 Type I Start	T5 Type I Start	DSX2
P1	P7		T5 Type I Start	T5 Type I Start	DSX2
P4	P6		T5 Type I Start	T5 Type I Start	DSX2

Accessories

DSX2 LED: 1.1 ft, 40" x 15", 7.14" x 3.5", 36lb

Options

DSX2 LED: 1.1 ft, 40" x 15", 7.14" x 3.5", 36lb

Drilling

DSX2 LED: 1.1 ft, 40" x 15", 7.14" x 3.5", 36lb



D-Series Size 1 LED Area Luminaire

Specifications

EPA: 1.0 ft
Length: 35"
Width: 13"
Height 1: 7.14"
Height 2: 3.12"
Weight: 27 lb

Ordering Information

EXAMPLE: DSX1 LED P7 40K T3M MVOLT SPA NLTAIR2 PIRHN DBB2D

DSX1 LED	LEDs	Color Temperature	DSX1 Features	Accessories	Mounting
DSX1 LED	Forward optics	30K 3000K	T5 Type I Start	T5 Type I Start	DSX1
P1	P2	40K 4000K	T5 Type I Start	T5 Type I Start	DSX1
P2	P6	50K 5000K	T5 Type I Start	T5 Type I Start	DSX1
P1	P7		T5 Type I Start	T5 Type I Start	DSX1
P4	P6		T5 Type I Start	T5 Type I Start	DSX1
DSX1 LED	Recessed optics		T5 Type I Start	T5 Type I Start	DSX1
P1	P2		T5 Type I Start	T5 Type I Start	DSX1
P4	P6		T5 Type I Start	T5 Type I Start	DSX1
P1	P7		T5 Type I Start	T5 Type I Start	DSX1
P4	P6		T5 Type I Start	T5 Type I Start	DSX1

Accessories

DSX1 LED: 1.0 ft, 35" x 13", 7.14" x 3.12", 27 lb

Options

DSX1 LED: 1.0 ft, 35" x 13", 7.14" x 3.12", 27 lb

Drilling

DSX1 LED: 1.0 ft, 35" x 13", 7.14" x 3.12", 27 lb

TYPE B LIGHTING FIXTURE



D-Series Size 2 LED Wall Luminaire

Specifications

EPA: 1.1 ft
Length: 40"
Width: 15"
Height 1: 7.14"
Height 2: 3.5"
Weight: 36lb

Ordering Information

EXAMPLE: DSX2 LED P7 40K T3M MVOLT SPA NLTAIR2 PIRHN DBB2D

DSX2 LED	LEDs	Color Temperature	DSX2 Features	Accessories	Mounting
DSX2 LED	Forward optics	30K 3000K	T5 Type I Start	T5 Type I Start	DSX2
P1	P2	40K 4000K	T5 Type I Start	T5 Type I Start	DSX2
P2	P6	50K 5000K	T5 Type I Start	T5 Type I Start	DSX2
P1	P7		T5 Type I Start	T5 Type I Start	DSX2
P4	P6		T5 Type I Start	T5 Type I Start	DSX2
DSX2 LED	Recessed optics		T5 Type I Start	T5 Type I Start	DSX2
P1	P2		T5 Type I Start	T5 Type I Start	DSX2
P4	P6		T5 Type I Start	T5 Type I Start	DSX2
P1	P7		T5 Type I Start	T5 Type I Start	DSX2
P4	P6		T5 Type I Start	T5 Type I Start	DSX2

Accessories

DSX2 LED: 1.1 ft, 40" x 15", 7.14" x 3.5", 36lb

Options

DSX2 LED: 1.1 ft, 40" x 15", 7.14" x 3.5", 36lb

Drilling

DSX2 LED: 1.1 ft, 40" x 15", 7.14" x 3.5", 36lb



D-Series Size 1 LED Wall Luminaire

Specifications

EPA: 1.0 ft
Length: 35"
Width: 13"
Height 1: 7.14"
Height 2: 3.12"
Weight: 27 lb

Ordering Information

EXAMPLE: DSX1 LED P7 40K T3M MVOLT SPA NLTAIR2 PIRHN DBB2D

DSX1 LED	LEDs	Color Temperature	DSX1 Features	Accessories	Mounting
DSX1 LED	Forward optics	30K 3000K	T5 Type I Start	T5 Type I Start	DSX1
P1	P2	40K 4000K	T5 Type I Start	T5 Type I Start	DSX1
P2	P6	50K 5000K	T5 Type I Start	T5 Type I Start	DSX1
P1	P7		T5 Type I Start	T5 Type I Start	DSX1
P4	P6		T5 Type I Start	T5 Type I Start	DSX1
DSX1 LED	Recessed optics		T5 Type I Start	T5 Type I Start	DSX1
P1	P2		T5 Type I Start	T5 Type I Start	DSX1
P4	P6		T5 Type I Start	T5 Type I Start	DSX1
P1	P7		T5 Type I Start	T5 Type I Start	DSX1
P4	P6		T5 Type I Start	T5 Type I Start	DSX1

Accessories

DSX1 LED: 1.0 ft, 35" x 13", 7.14" x 3.12", 27 lb

Options

DSX1 LED: 1.0 ft, 35" x 13", 7.14" x 3.12", 27 lb

Drilling

DSX1 LED: 1.0 ft, 35" x 13", 7.14" x 3.12", 27 lb

TYPE C LIGHTING FIXTURE



D-Series Size 2 LED Wall Luminaire

Specifications

EPA: 1.1 ft
Length: 40"
Width: 15"
Height 1: 7.14"
Height 2: 3.5"
Weight: 36lb

Ordering Information

EXAMPLE: DSX2 LED P7 40K T3M MVOLT DBB2D

DSX2 LED	LEDs	Color Temperature	DSX2 Features	Accessories	Mounting
DSX2 LED	Forward optics	30K 3000K	T5 Type I Start	T5 Type I Start	DSX2
P1	P2	40K 4000K	T5 Type I Start	T5 Type I Start	DSX2
P2	P6	50K 5000K	T5 Type I Start	T5 Type I Start	DSX2
P1	P7		T5 Type I Start	T5 Type I Start	DSX2
P4	P6		T5 Type I Start	T5 Type I Start	DSX2
DSX2 LED	Recessed optics		T5 Type I Start	T5 Type I Start	DSX2
P1	P2		T5 Type I Start	T5 Type I Start	DSX2
P4	P6		T5 Type I Start	T5 Type I Start	DSX2
P1	P7		T5 Type I Start	T5 Type I Start	DSX2
P4	P6		T5 Type I Start	T5 Type I Start	DSX2

Accessories

DSX2 LED: 1.1 ft, 40" x 15", 7.14" x 3.5", 36lb

Options

DSX2 LED: 1.1 ft, 40" x 15", 7.14" x 3.5", 36lb

Drilling

DSX2 LED: 1.1 ft, 40" x 15", 7.14" x 3.5", 36lb



D-Series Size 1 LED Wall Luminaire

Specifications

EPA: 1.0 ft
Length: 35"
Width: 13"
Height 1: 7.14"
Height 2: 3.12"
Weight: 27 lb

Ordering Information

EXAMPLE: DSX1 LED P7 40K T3M MVOLT SPA NLTAIR2 PIRHN DBB2D

DSX1 LED	LEDs	Color Temperature	DSX1 Features	Accessories	Mounting
DSX1 LED	Forward optics	30K 3000K	T5 Type I Start	T5 Type I Start	DSX1
P1	P2	40K 4000K	T5 Type I Start	T5 Type I Start	DSX1
P2	P6	50K 5000K	T5 Type I Start	T5 Type I Start	DSX1
P1	P7		T5 Type I Start	T5 Type I Start	DSX1
P4	P6		T5 Type I Start	T5 Type I Start	DSX1
DSX1 LED	Recessed optics		T5 Type I Start	T5 Type I Start	DSX1
P1	P2		T5 Type I Start	T5 Type I Start	DSX1
P4	P6		T5 Type I Start	T5 Type I Start	DSX1
P1	P7		T5 Type I Start	T5 Type I Start	DSX1
P4	P6		T5 Type I Start	T5 Type I Start	DSX1

Accessories

DSX1 LED: 1.0 ft, 35" x 13", 7.14" x 3.12", 27 lb

Options

DSX1 LED: 1.0 ft, 35" x 13", 7.14" x 3.12", 27 lb

Drilling

DSX1 LED: 1.0 ft, 35" x 13", 7.14" x 3.12", 27 lb



KASTER ARCHITECTS INC.

9000 STATE LINE ROAD
LEAWOOD, KANSAS 66206

11008 PARALLEL PARKWAY
KANSAS CITY, KANSAS 64119

TEL (913) 642-6642
FAX (913) 642-6941
www.kasterarchitects.com

PRELIMINARY
NOT FOR CONSTRUCTION


DAVID A. KASTER
ARCHITECT
MICHAEL L. KASTER
ARCHITECT
COPYRIGHT © 2022 Kaster Architects, Inc.
7304 WEST 130th STREET
SUITE 170 PLAK, KANSAS 66213
TELEPHONE 616-1200
WEB SITE www.kasterarchitects.com

KASTER ARCHITECTS INC.

MIDWAY FORD
FORMER VATTEROTT BLDG.
4131 N. CORRINGTON AVE.
KANSAS CITY, MISSOURI

DATE: FEB. 8, 2023
REVISION: SHEET NUMBER
SL102
SITE LIGHTING
CATALOG CUT SHEETS
OF SHEETS
KAI JOB NO. 2214-A

811
Know what's below.
Call before you dig.

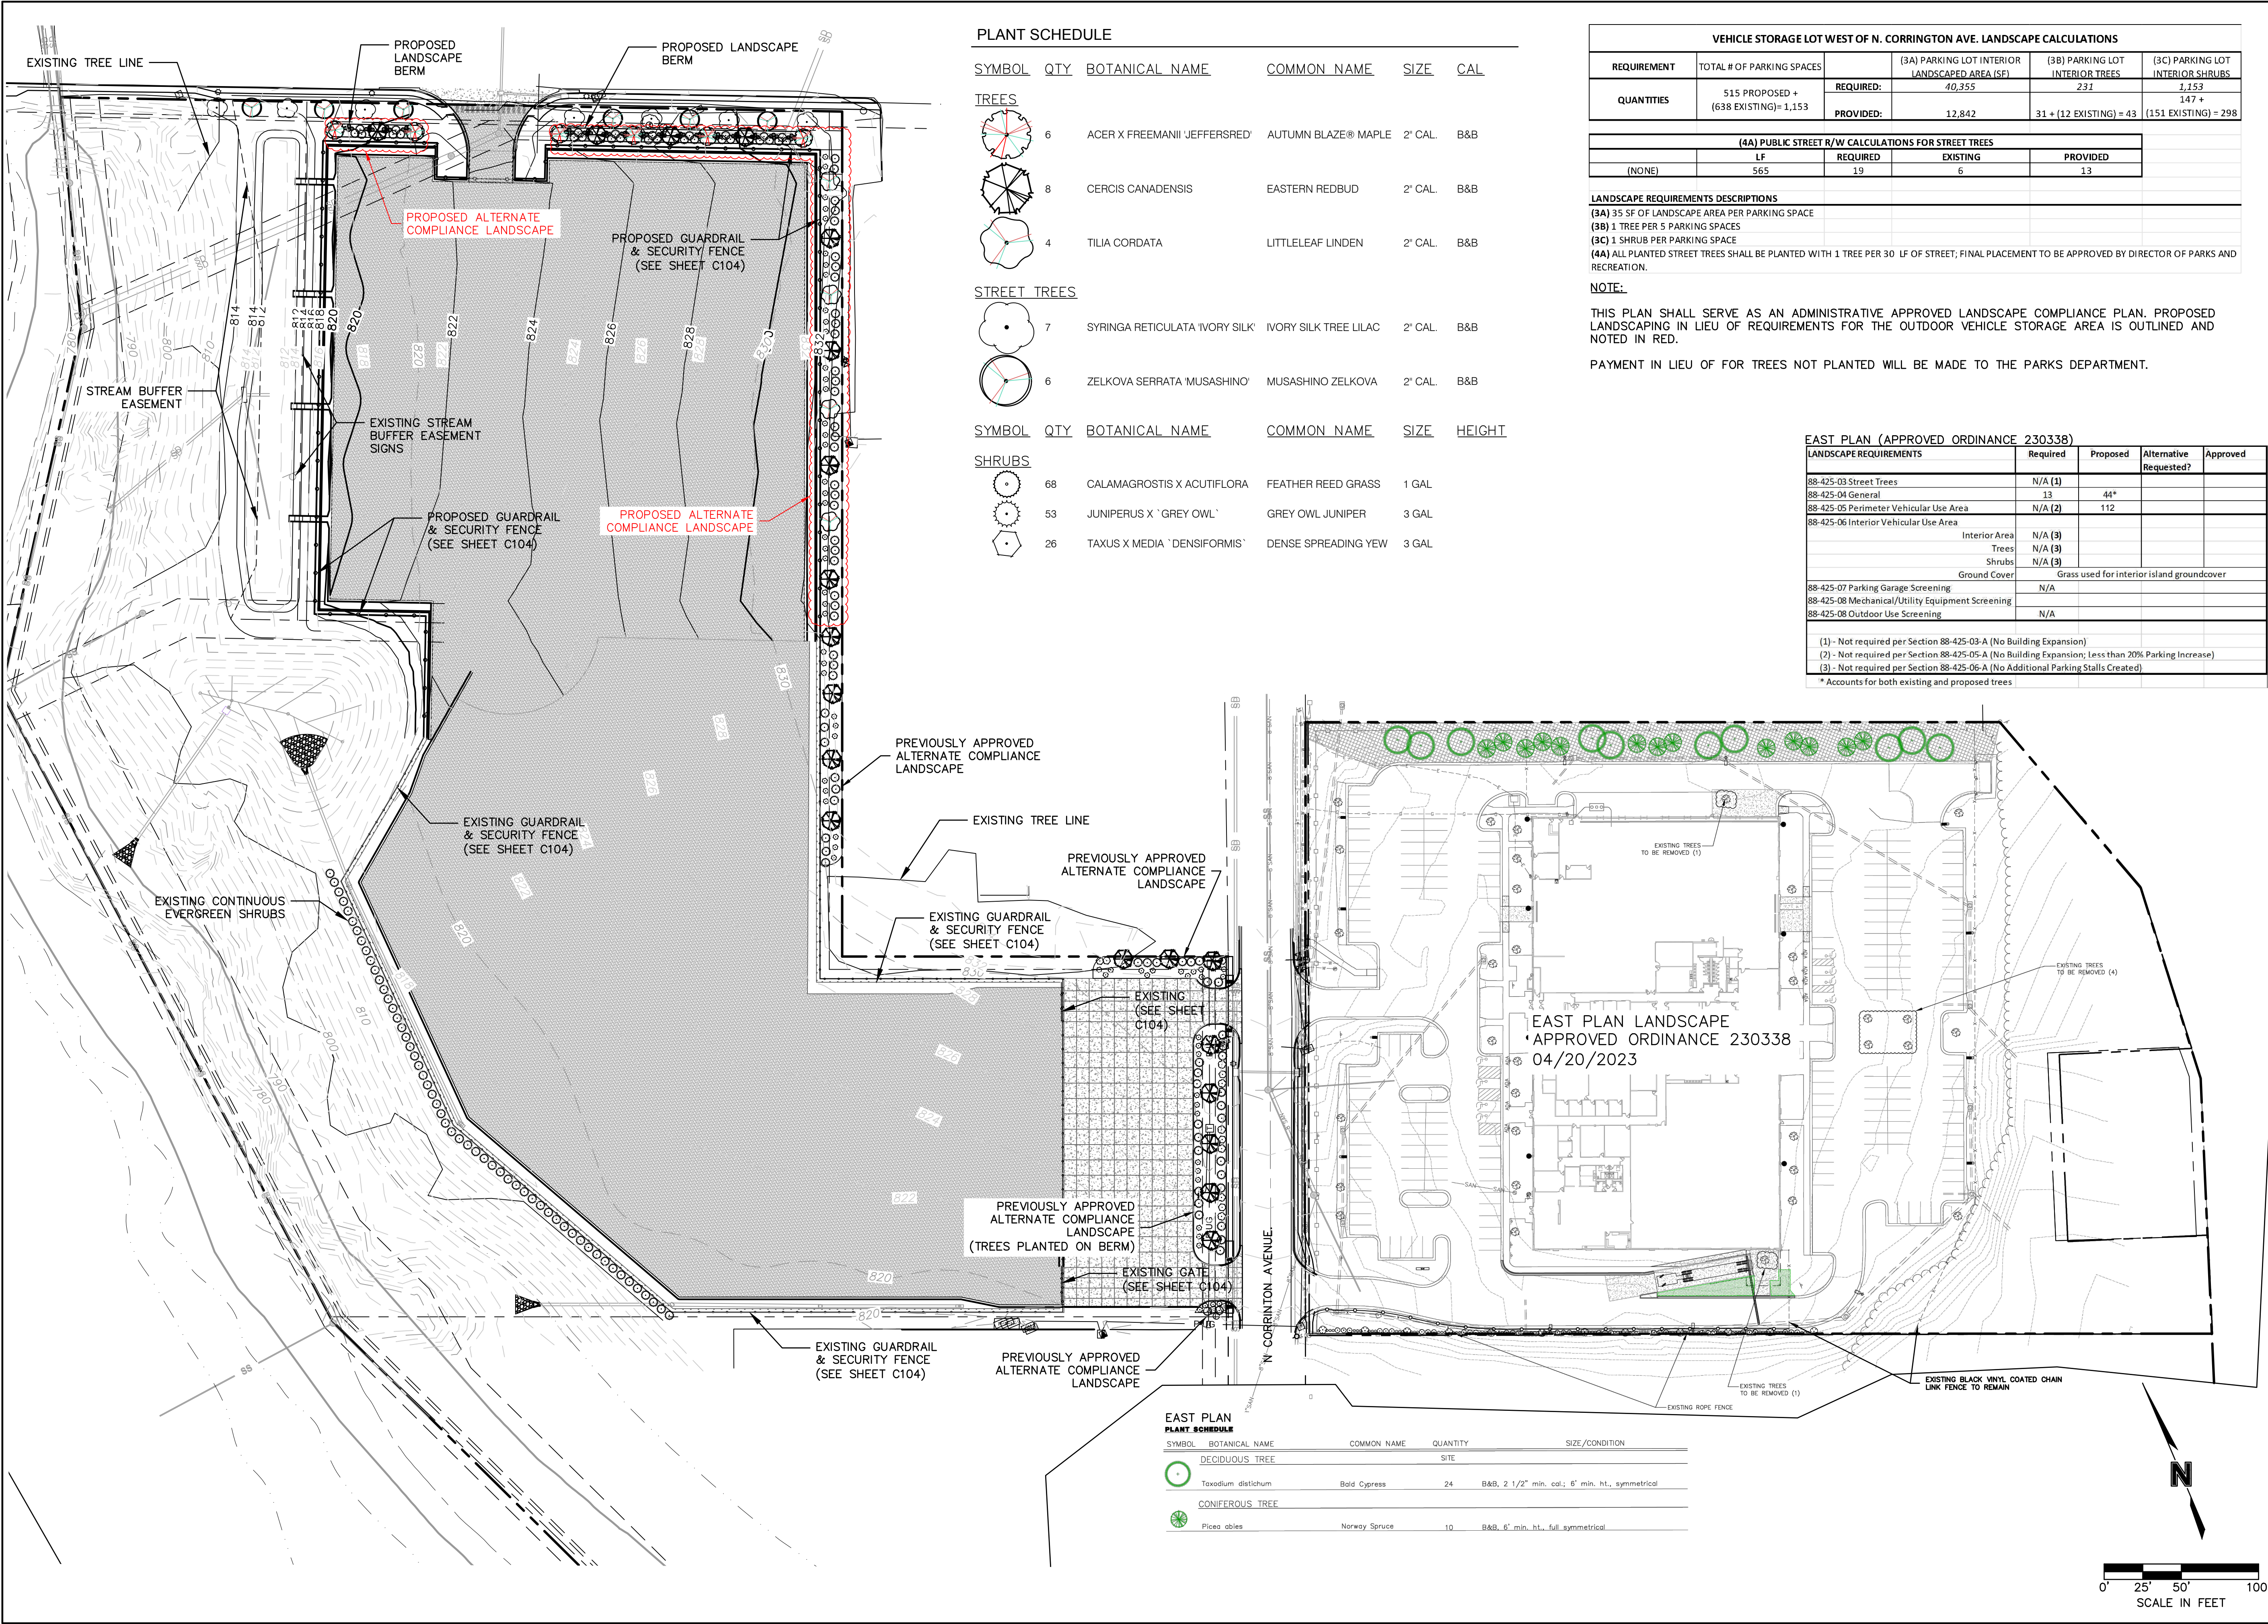

OLSSON ASSOCIATES, CIVIL ENGINEERING
1301 EURLINGTON, SUITE 100
NORTH KANSAS CITY, MO 64116
TEL 816.361.1177
WWW.OLSSON.COM

LANDSCAPE PLAN
DEVELOPMENT PLAN

MIDWAY FORD VEHICLE STAGING LOT
NE PARVIN & N CORRINGTON AVE

KANSAS CITY, MO

drawn by: JEQ
checked by: NH
designed by: JEQ
QA/QC by: NH
project no.: E23-00066
date: 03/31/25

SHEET
L101

REVISIONS DESCRIPTION

NO. REV. DATE



1 04/06/23

REVISED PER CITY COMMENTS




REVISIONS

2025


FOR REFERENCE (SEE ORBC-2022-40263)

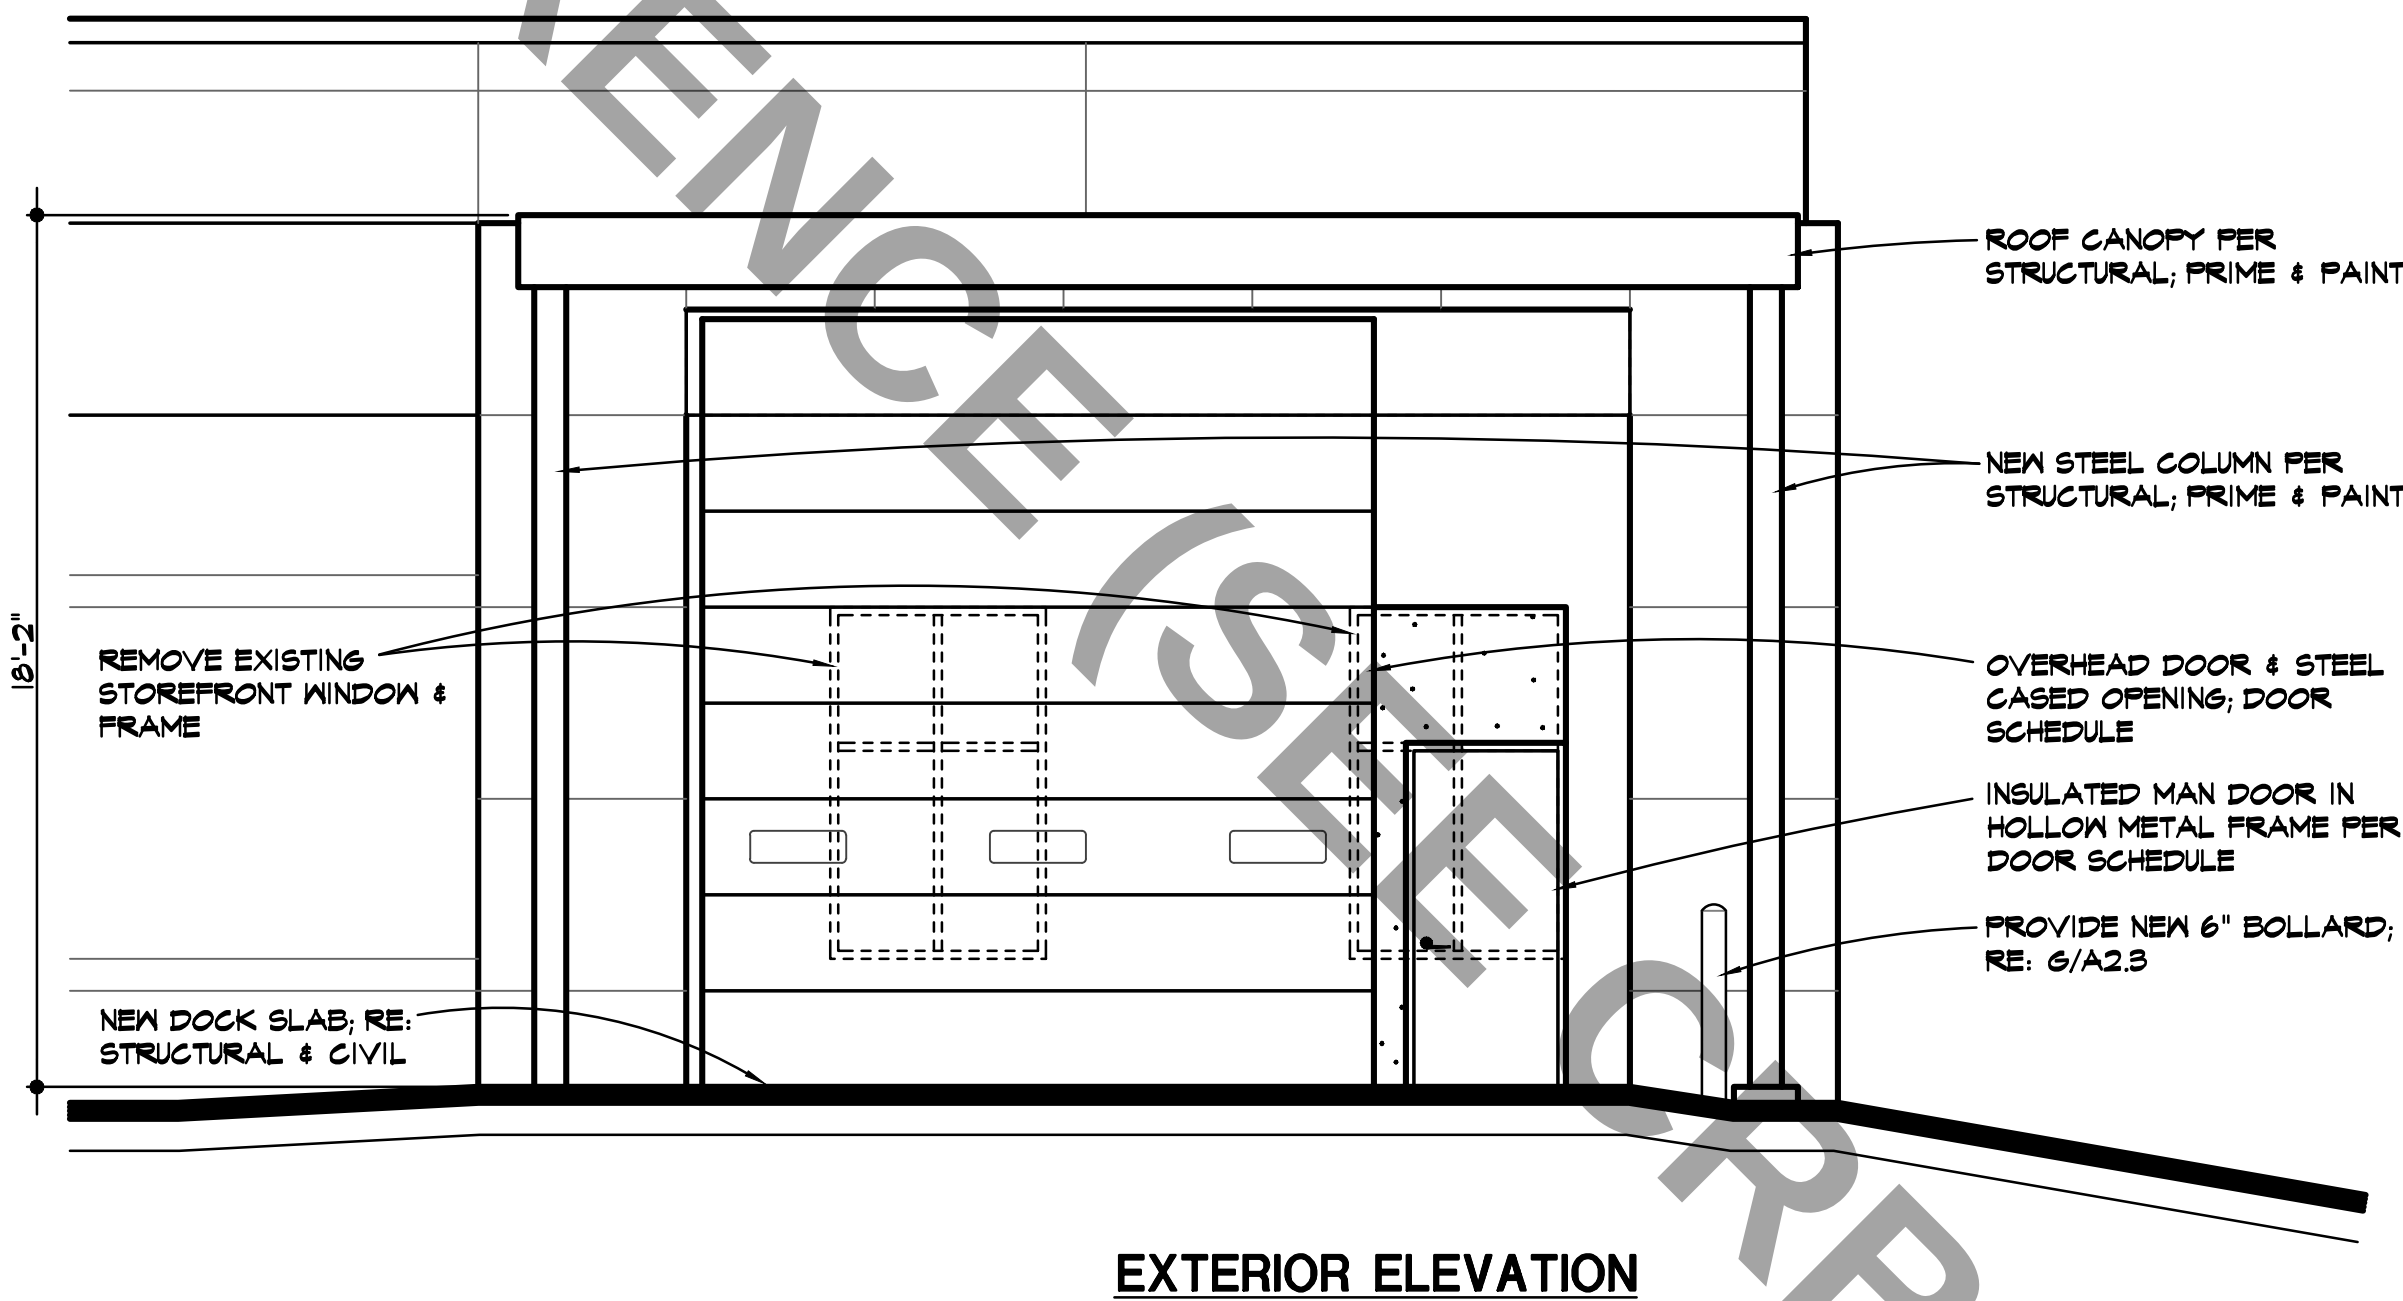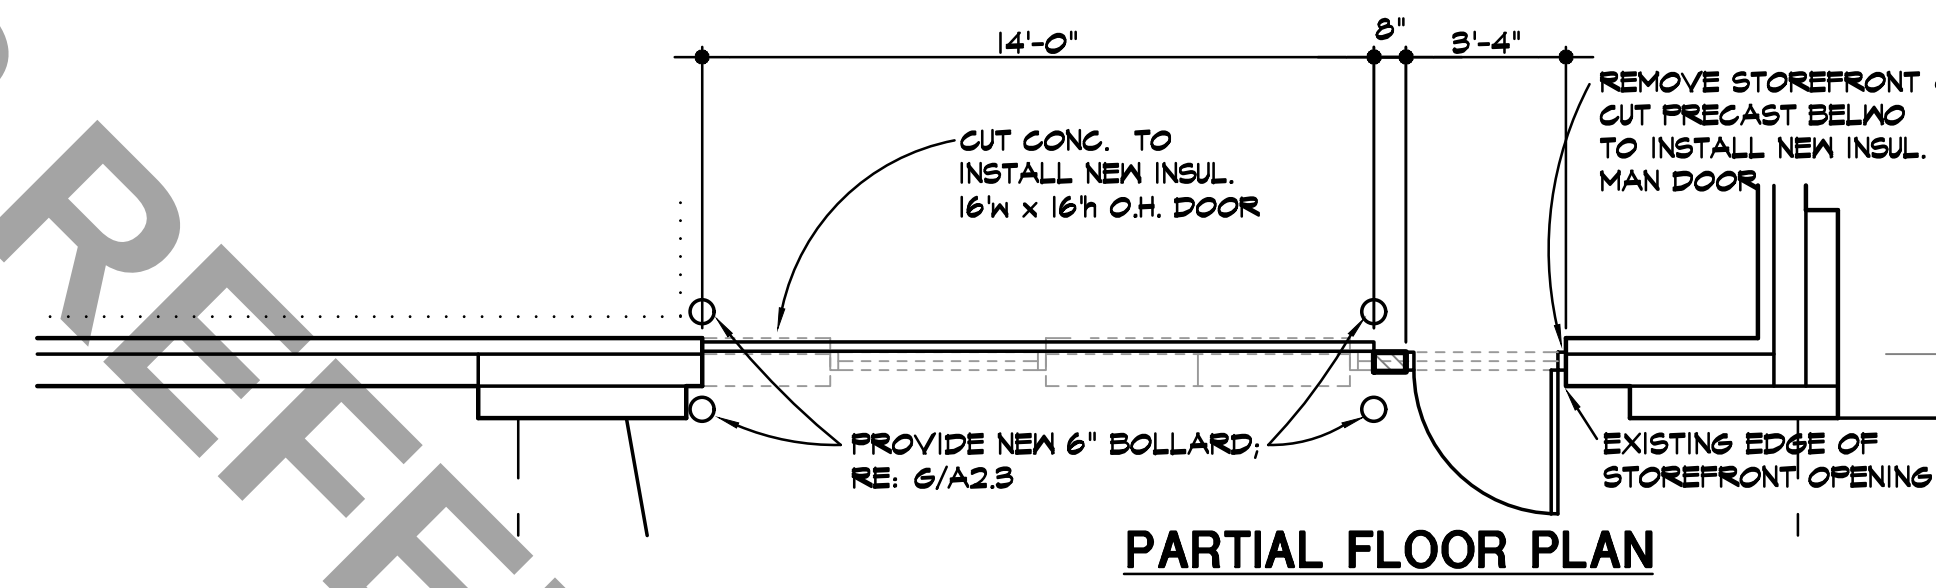


 
1 PARTS LOADING DOOR
A3.2 SCALE // 1/4" = 1'-0"

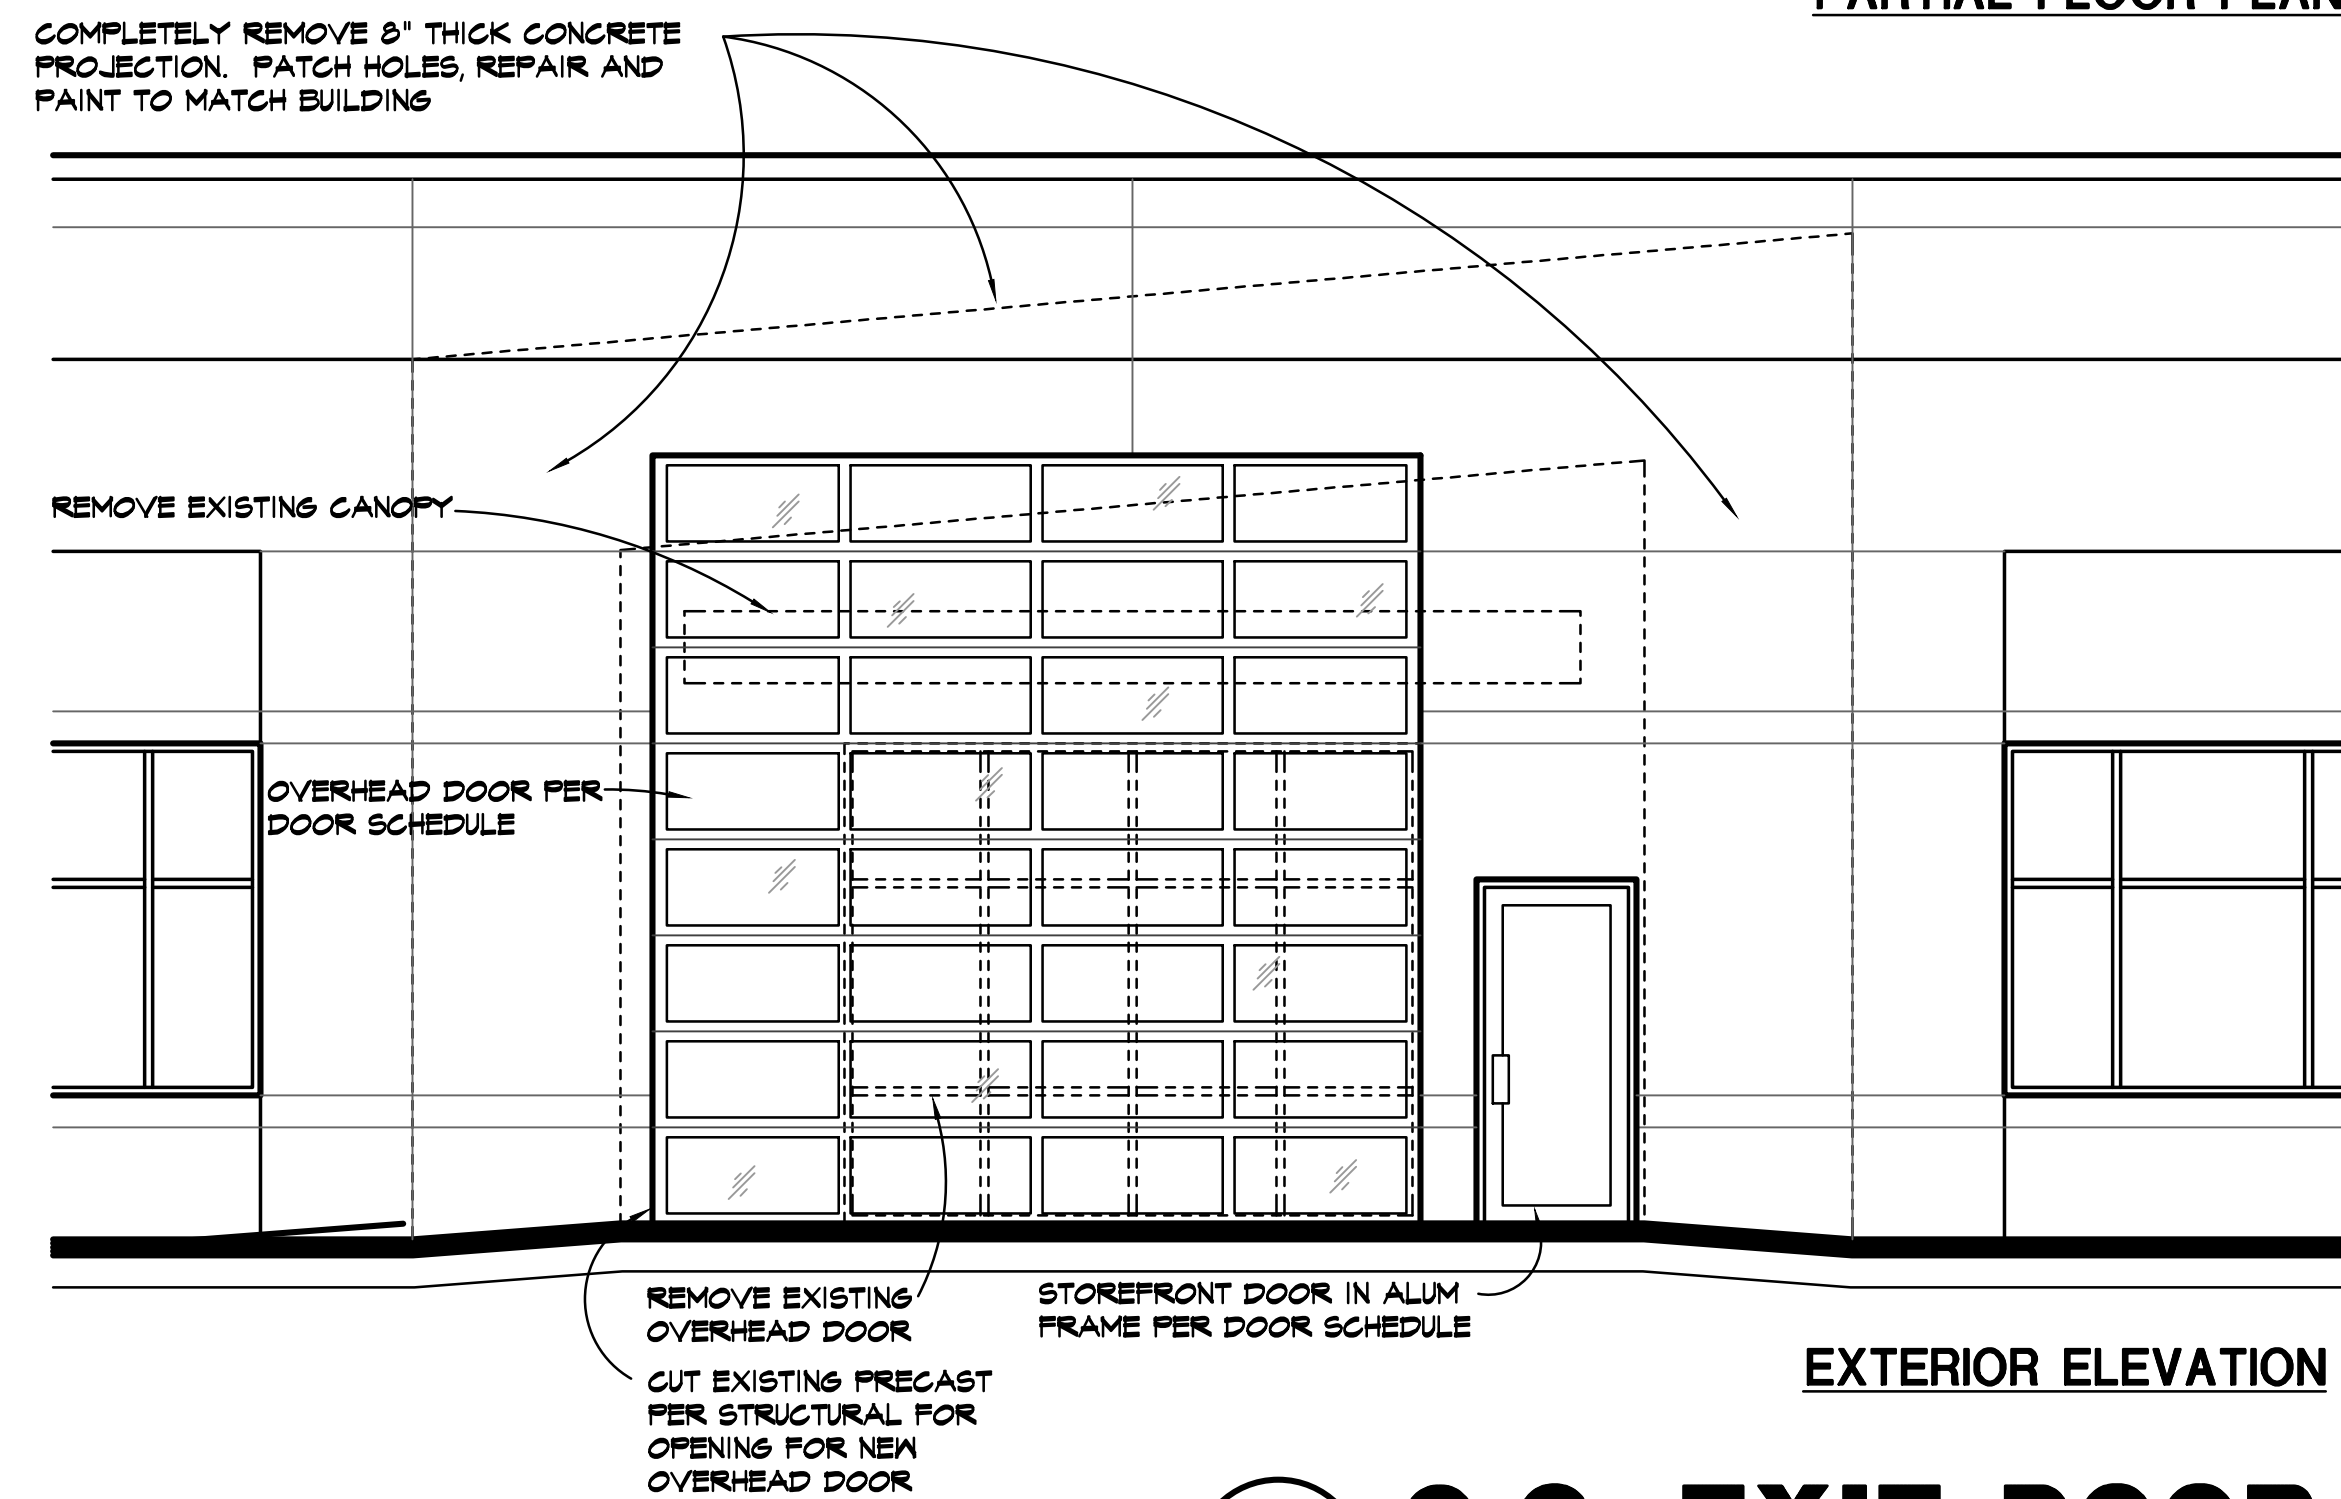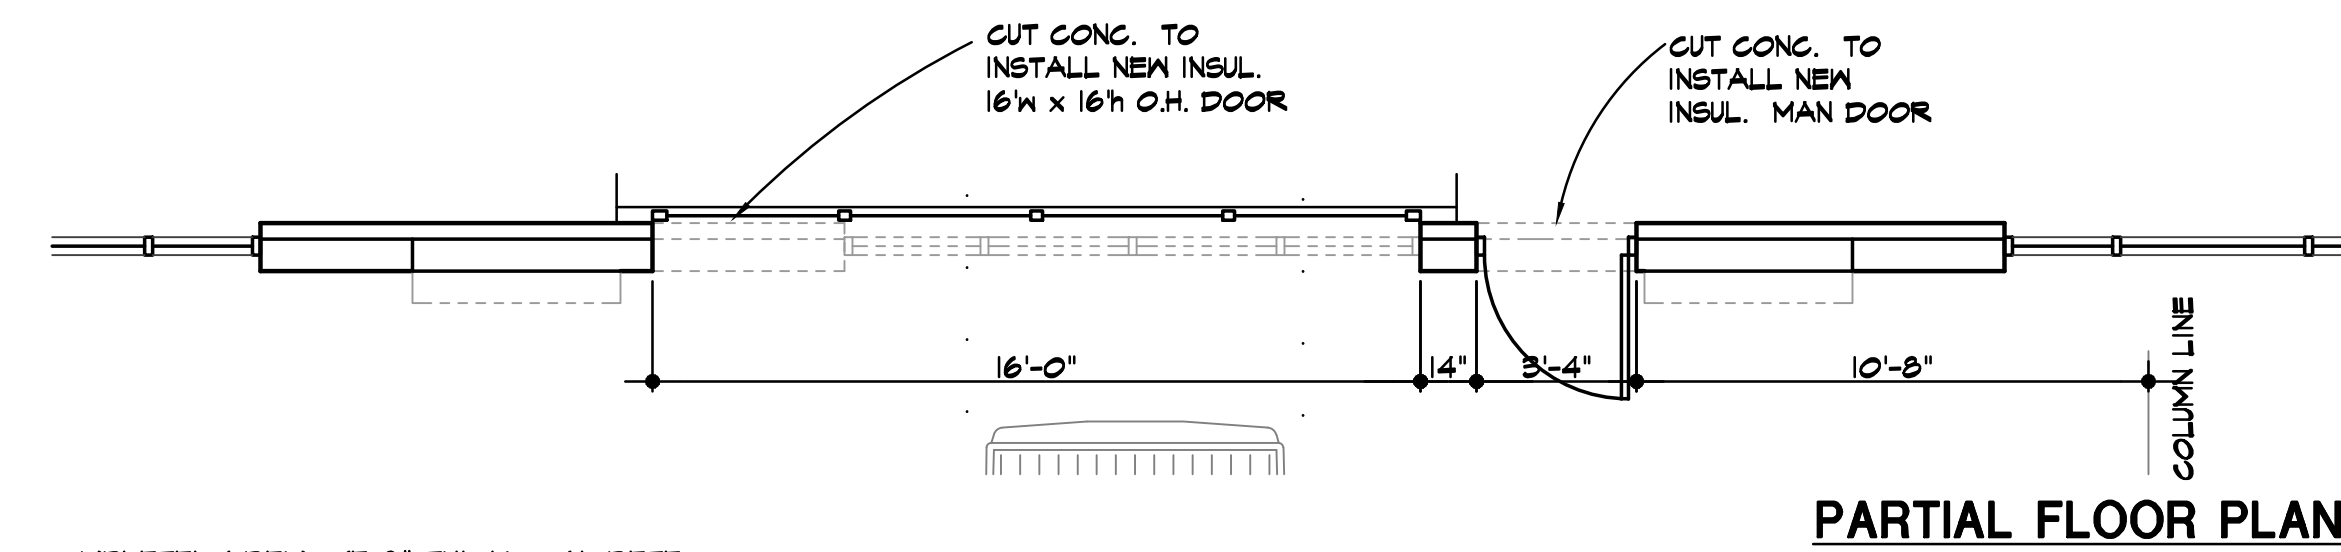



 
2 Q.C. EXIT DOOR
A3.2 SCALE // 1/4" = 1'-0"




NOTE:
• ALL SAWCUTS IMPACTING EXISTING PRECAST PANELS MUST BE REINFORCED AS INDICATED BY STRUCTURAL

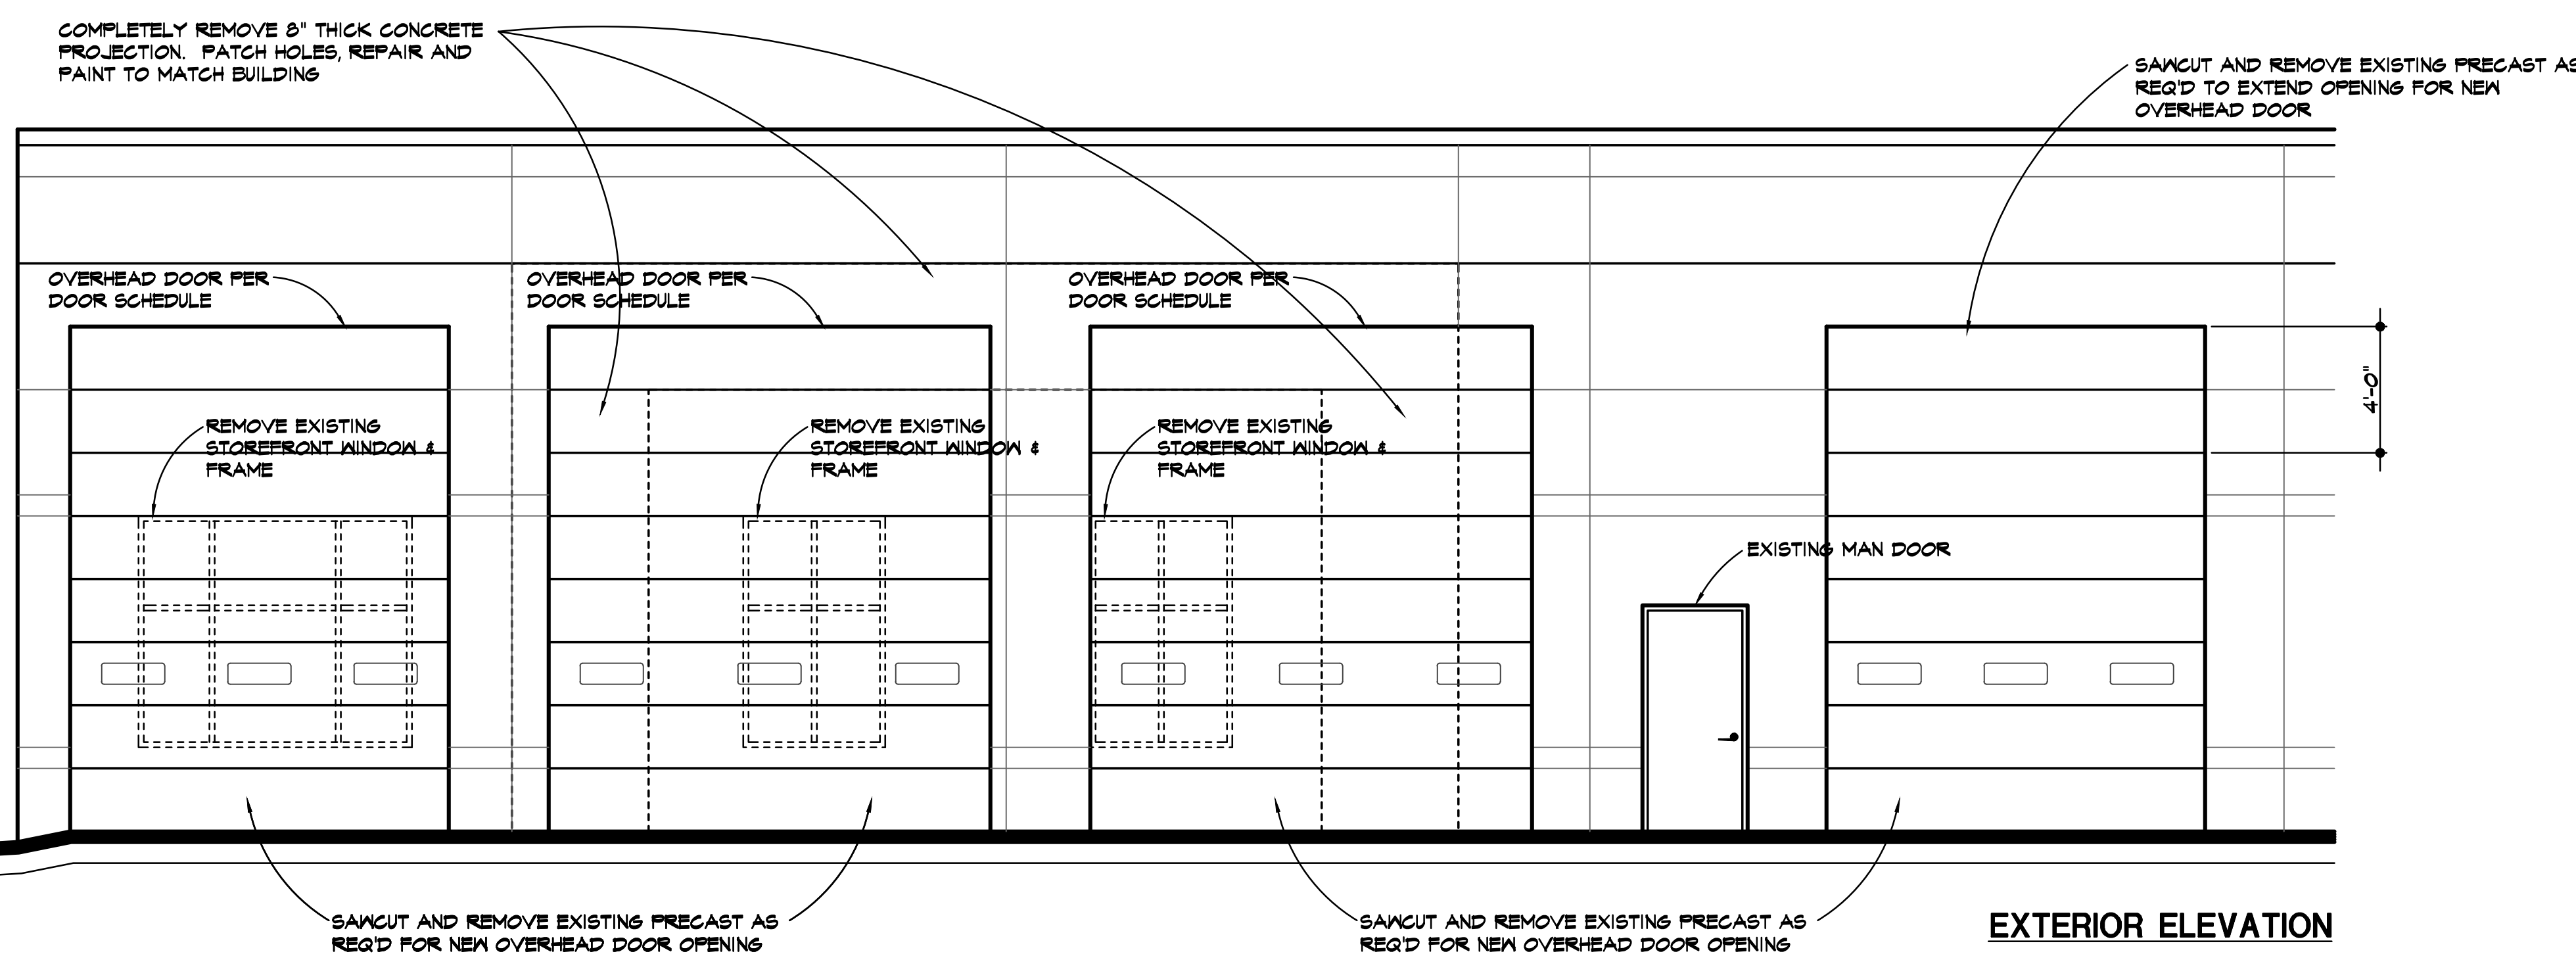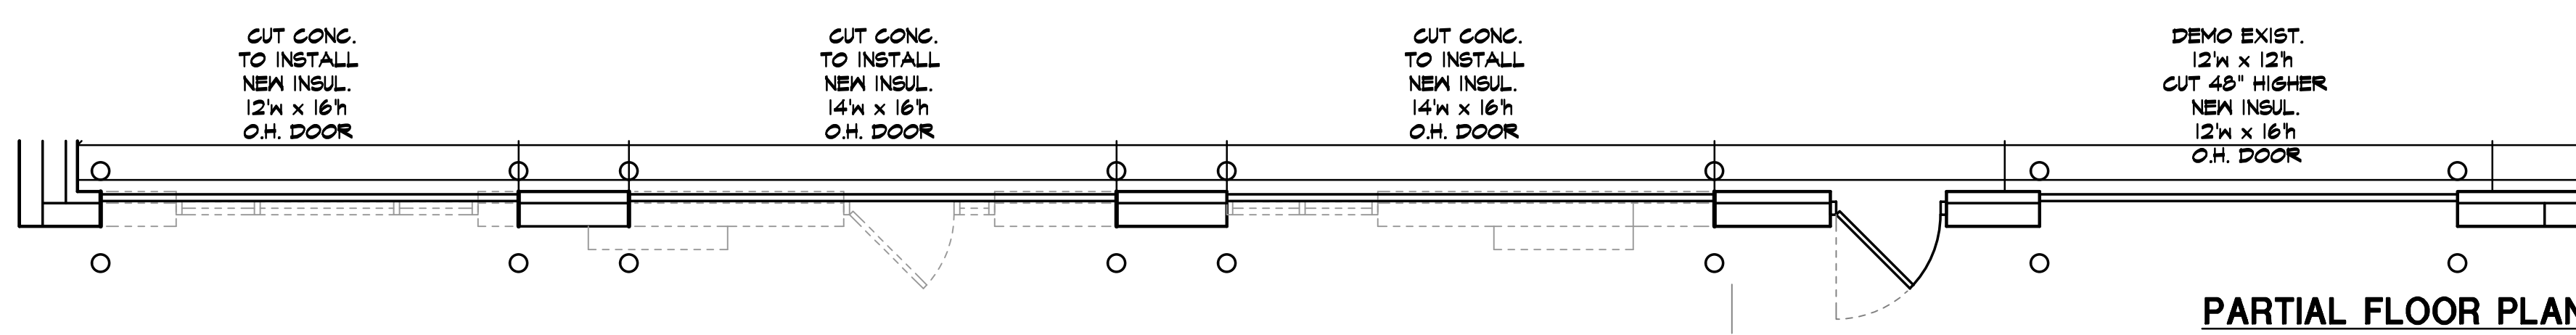

 3 SERVICE DOORS
A3.2 SCALE // 1/4" = 1'-0"

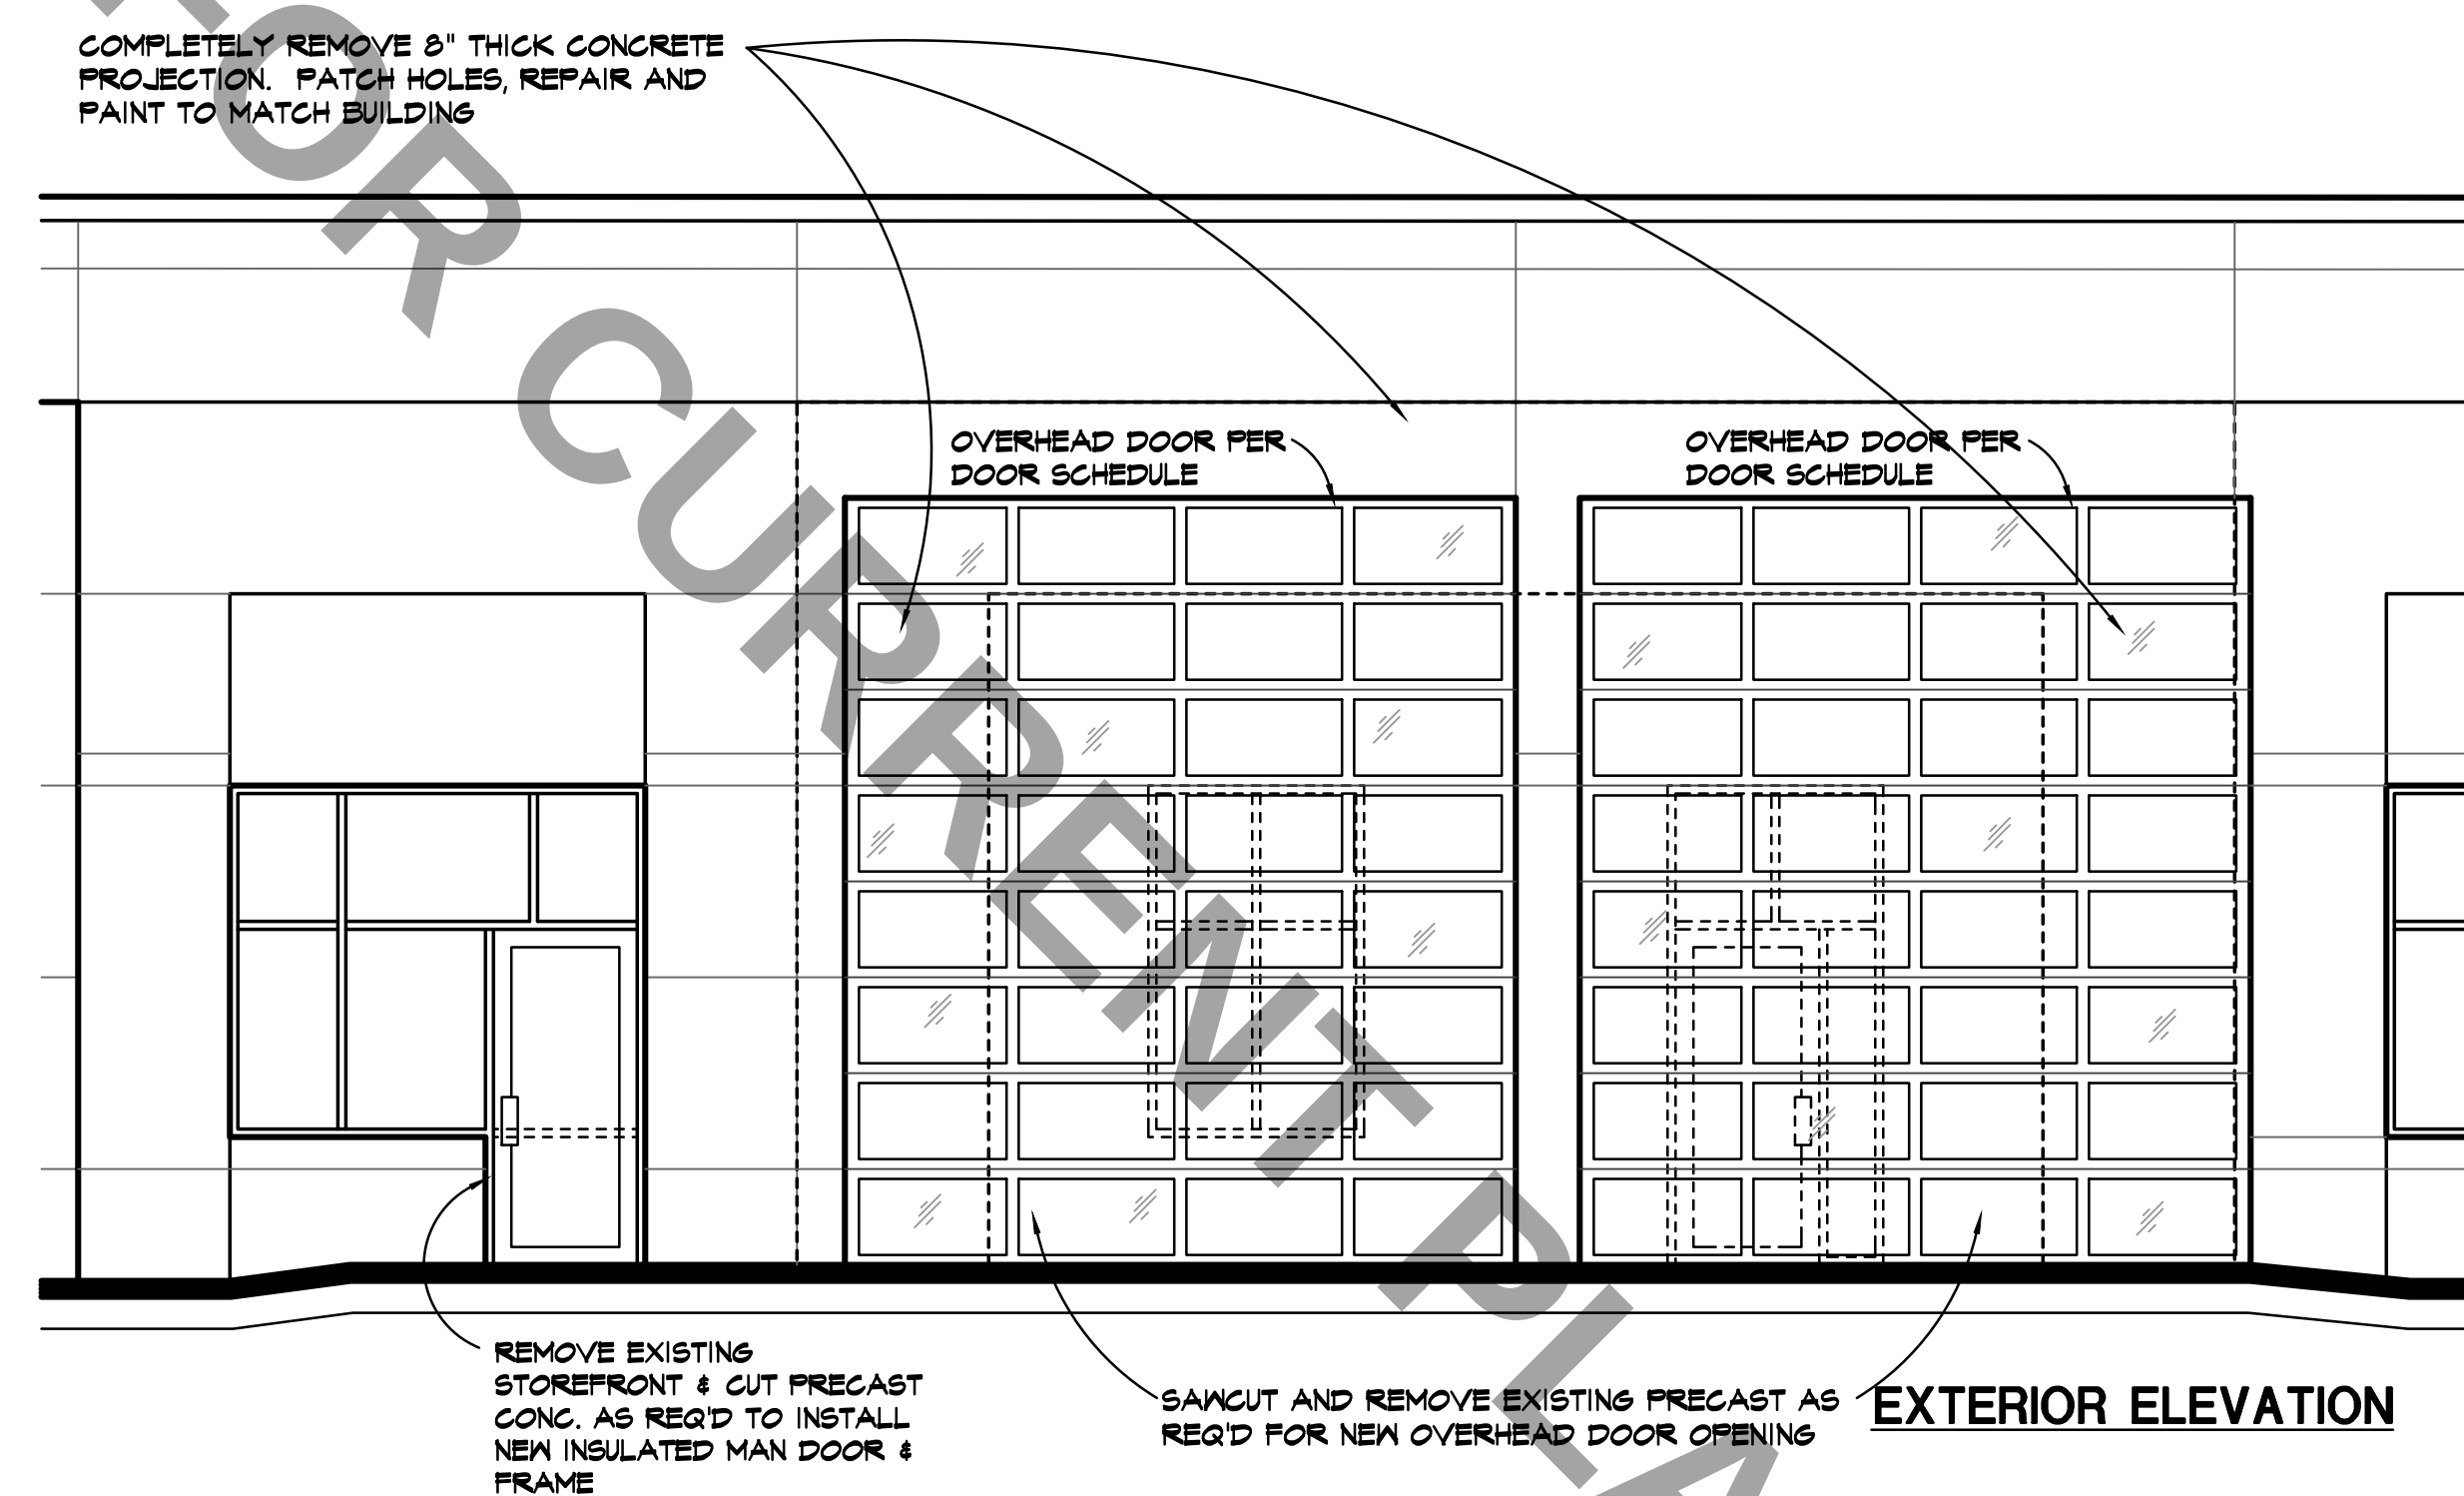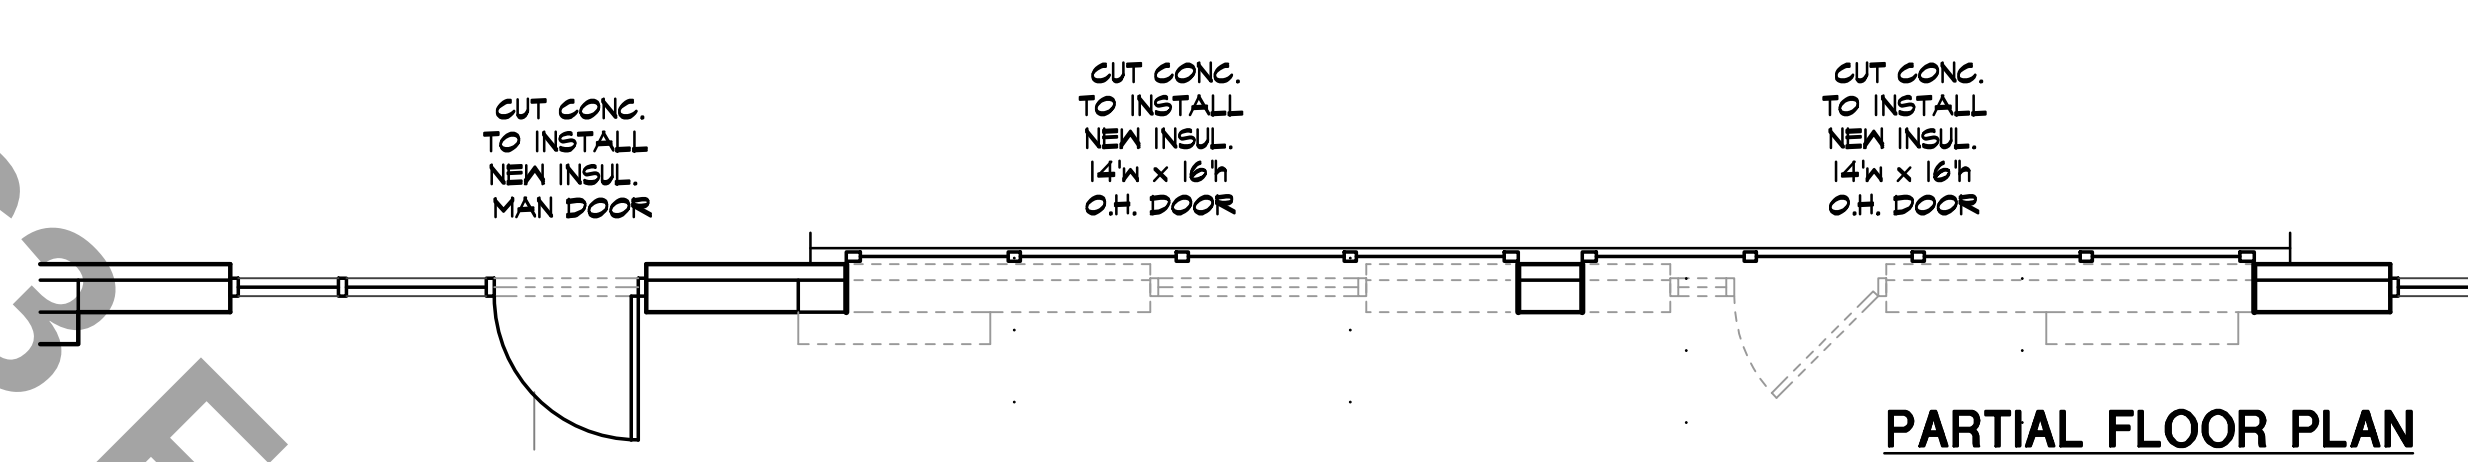

 4 Q.C. ENTRANCE DOORS
A3.2 SCALE // 1/4" = 1'-0"



DAVID A. KASTER, ARCHITECT
MICHAEL L. HOWARD, ARCHITECT
Copyright © 2022 Kaster Architects, Inc.
7304 WEST 130th STREET
SUITE 170 PARK, KANSAS 66213
TELEPHONE (813) 681-1200
WEB SITE www.kasterarchitects.com

KASTER ARCHITECTS INC
ARCHITECTURE · PLANNING · INTERIOR DESIGN

MIDWAY FORD
FORMER VATTEROTT BLDG.
4131 N. CORRINGTON AVE.
KANSAS CITY, MISSOURI

DATE DEC. 22, 2022
REVISED
SHEET NUMBER
A3.2
OF SHEETS
KAI JOB NO. 2214-A